




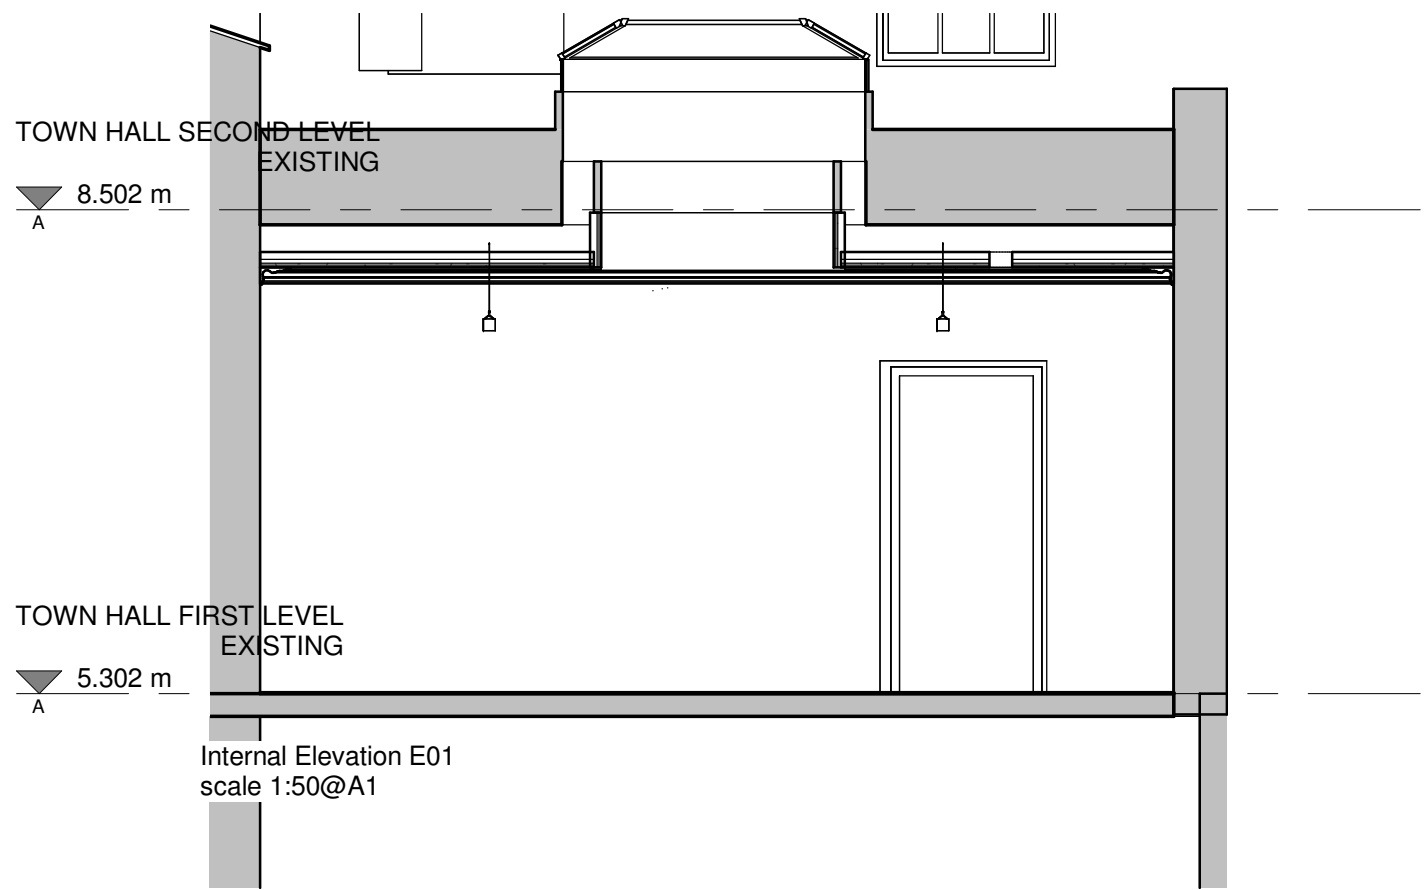


Internal Elevation E01
scale 1:50@A1

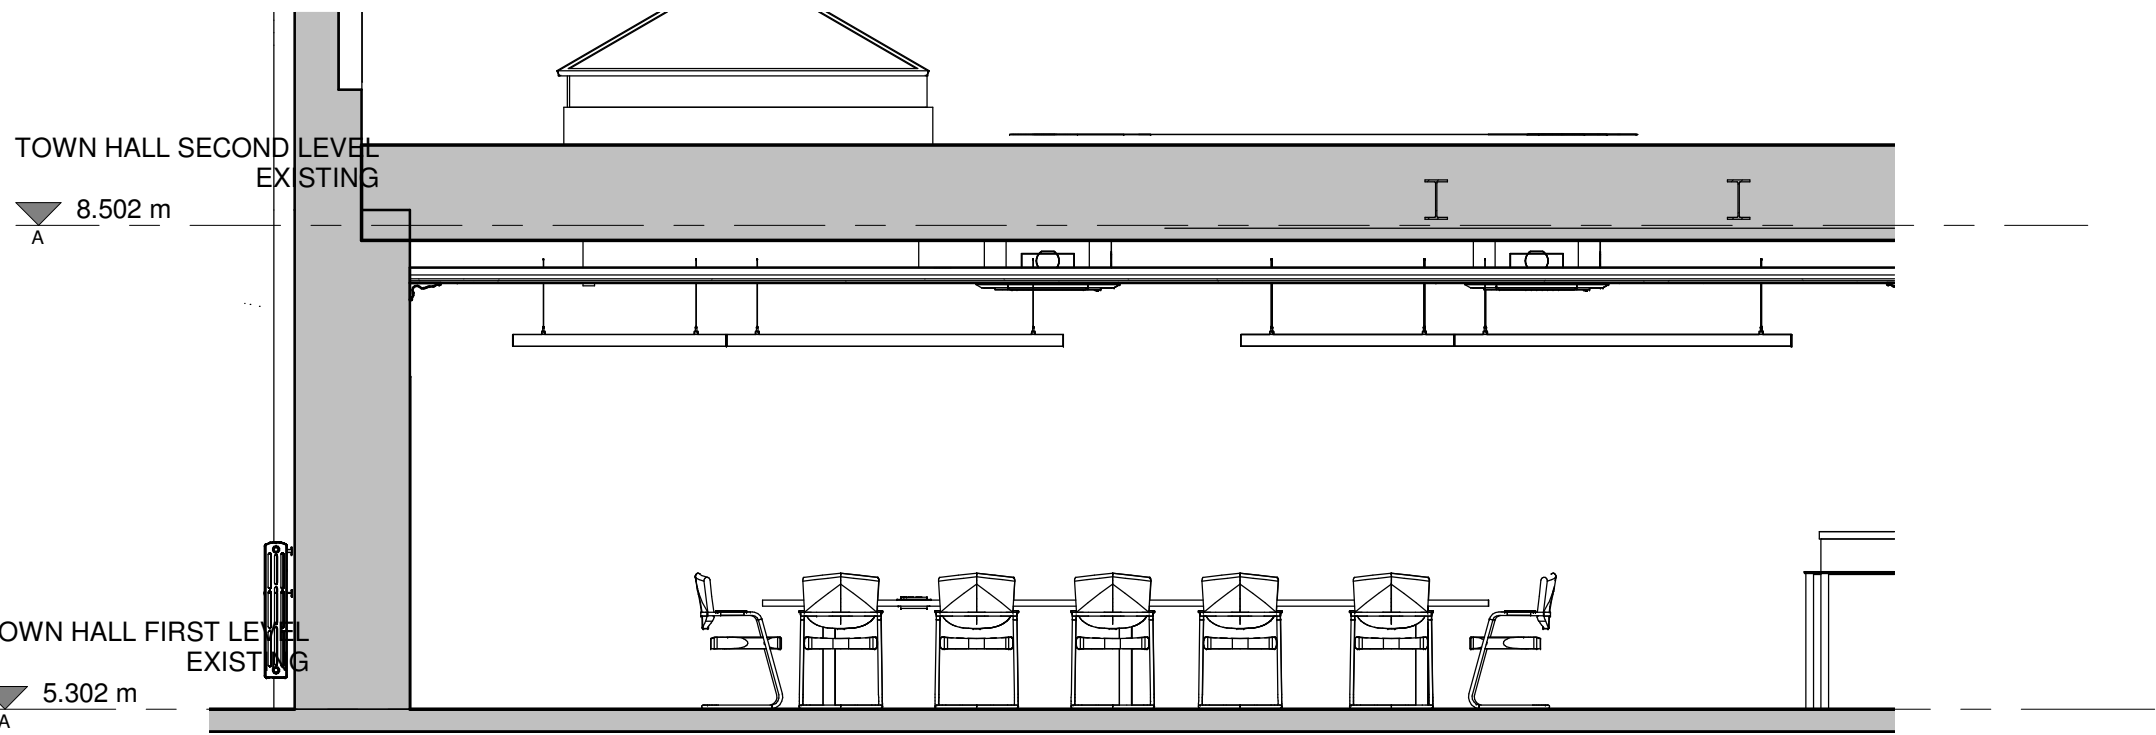


Internal Elevation E02
scale 1:50@A1

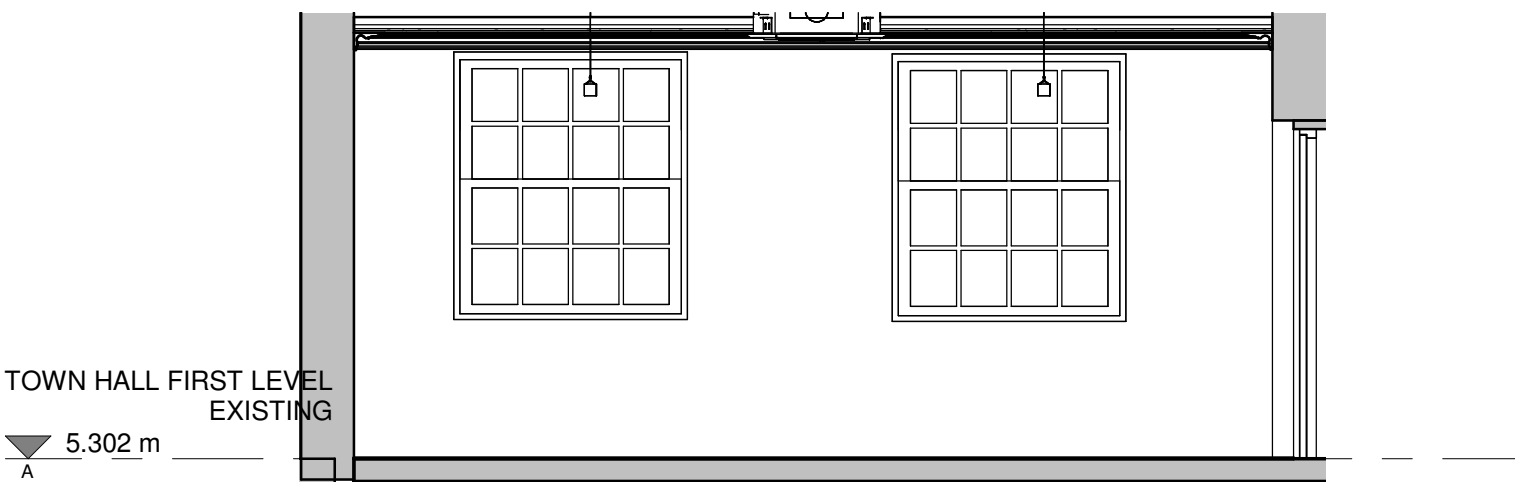

Internal Elevation E03
scale 1:50@A1

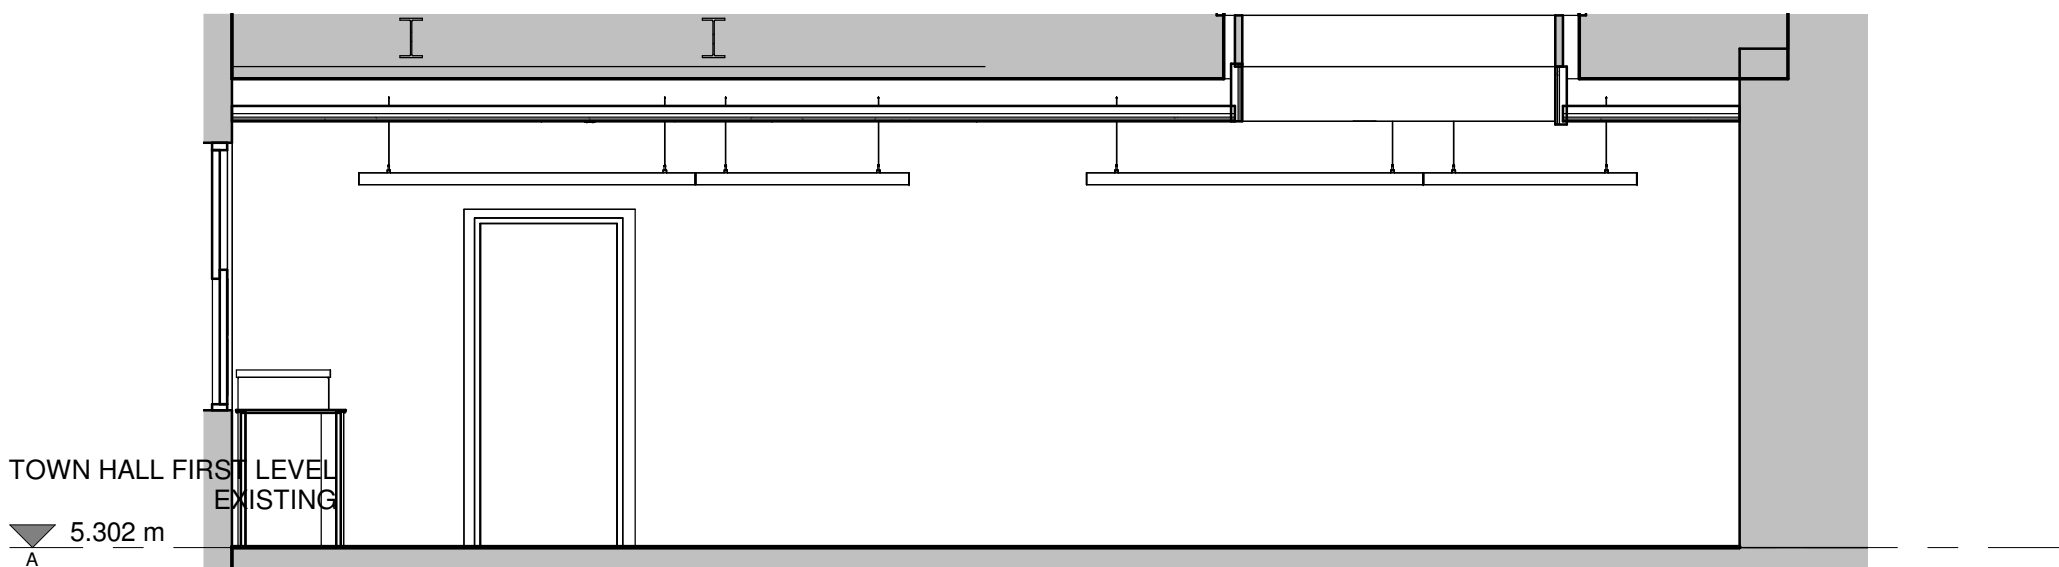

Internal Elevation E04
scale 1:50@A1

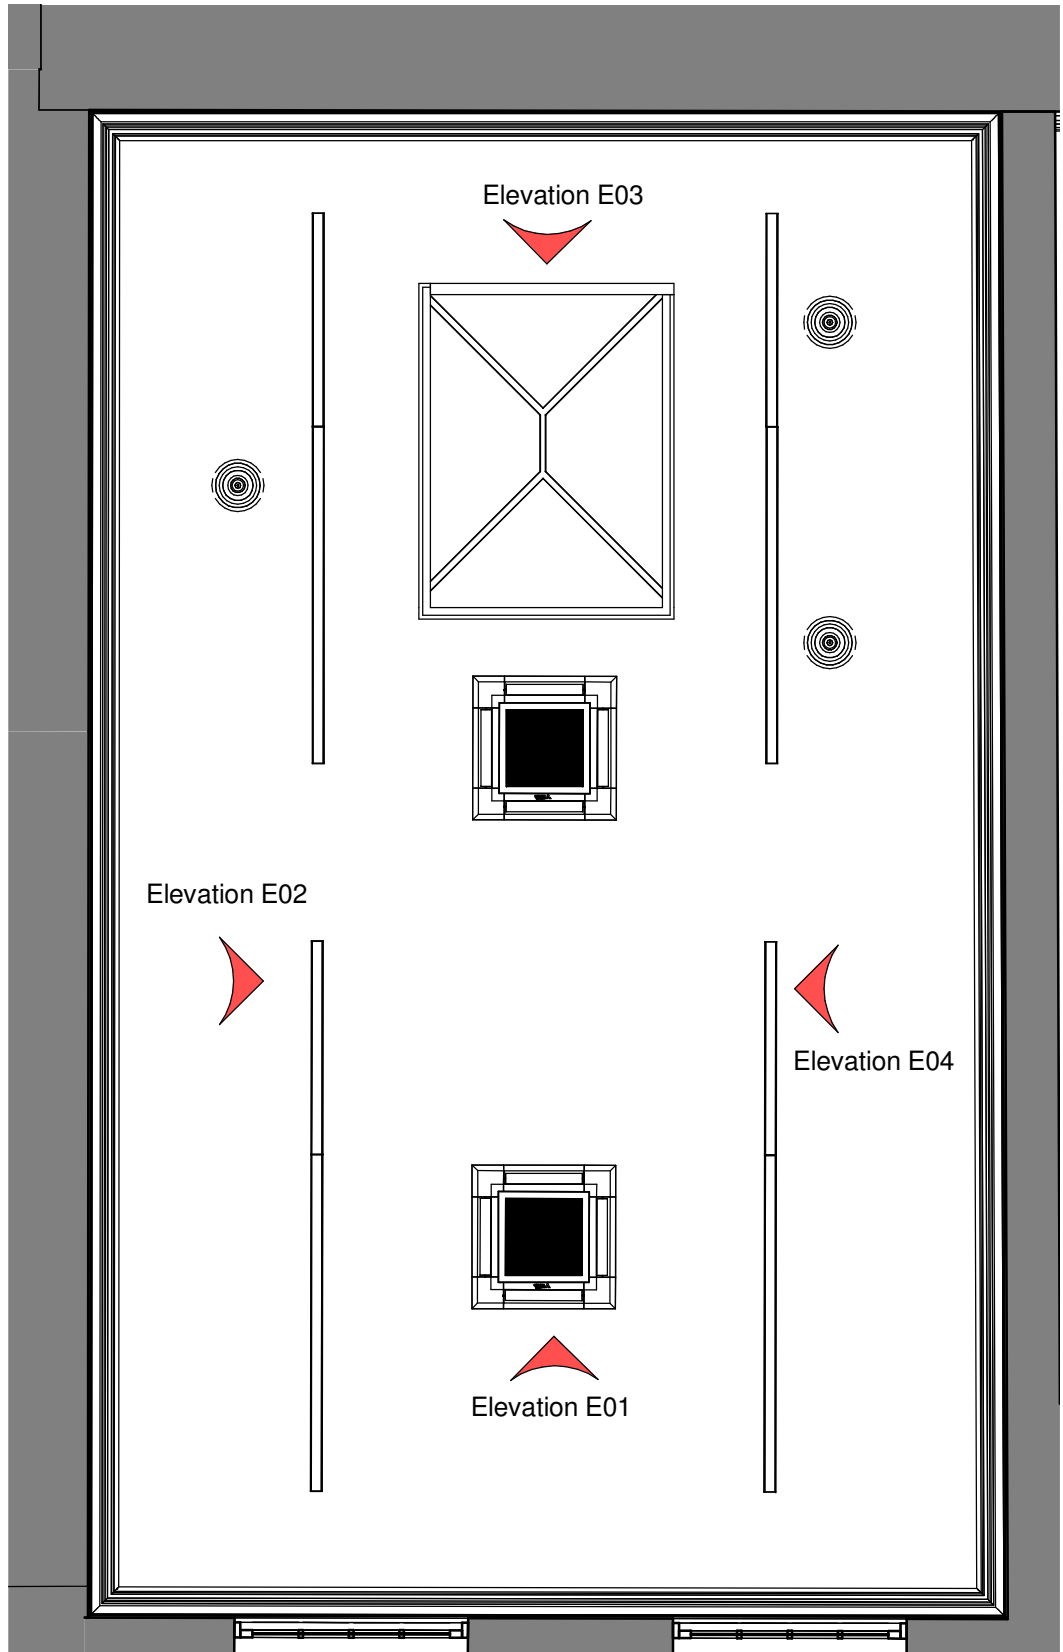

Court Room 3 Reflected Ceiling Plan
scale 1:50@A1



Thorlux Firefly recessed emergency light




Fagerhult Time square pendant light


Notes

⊗
THORLUX lighting - Firefly
Emergency Recessed Light


2250 and 1410
FAGERHULT - Time Square Pendant Linear LED

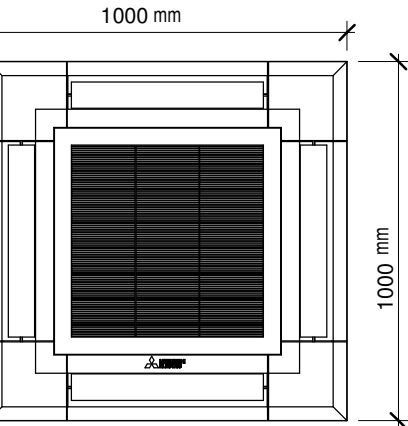


Air Conditioning Unit
4 way Cassette

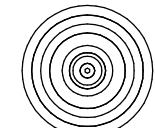

Supply / Extract Grill

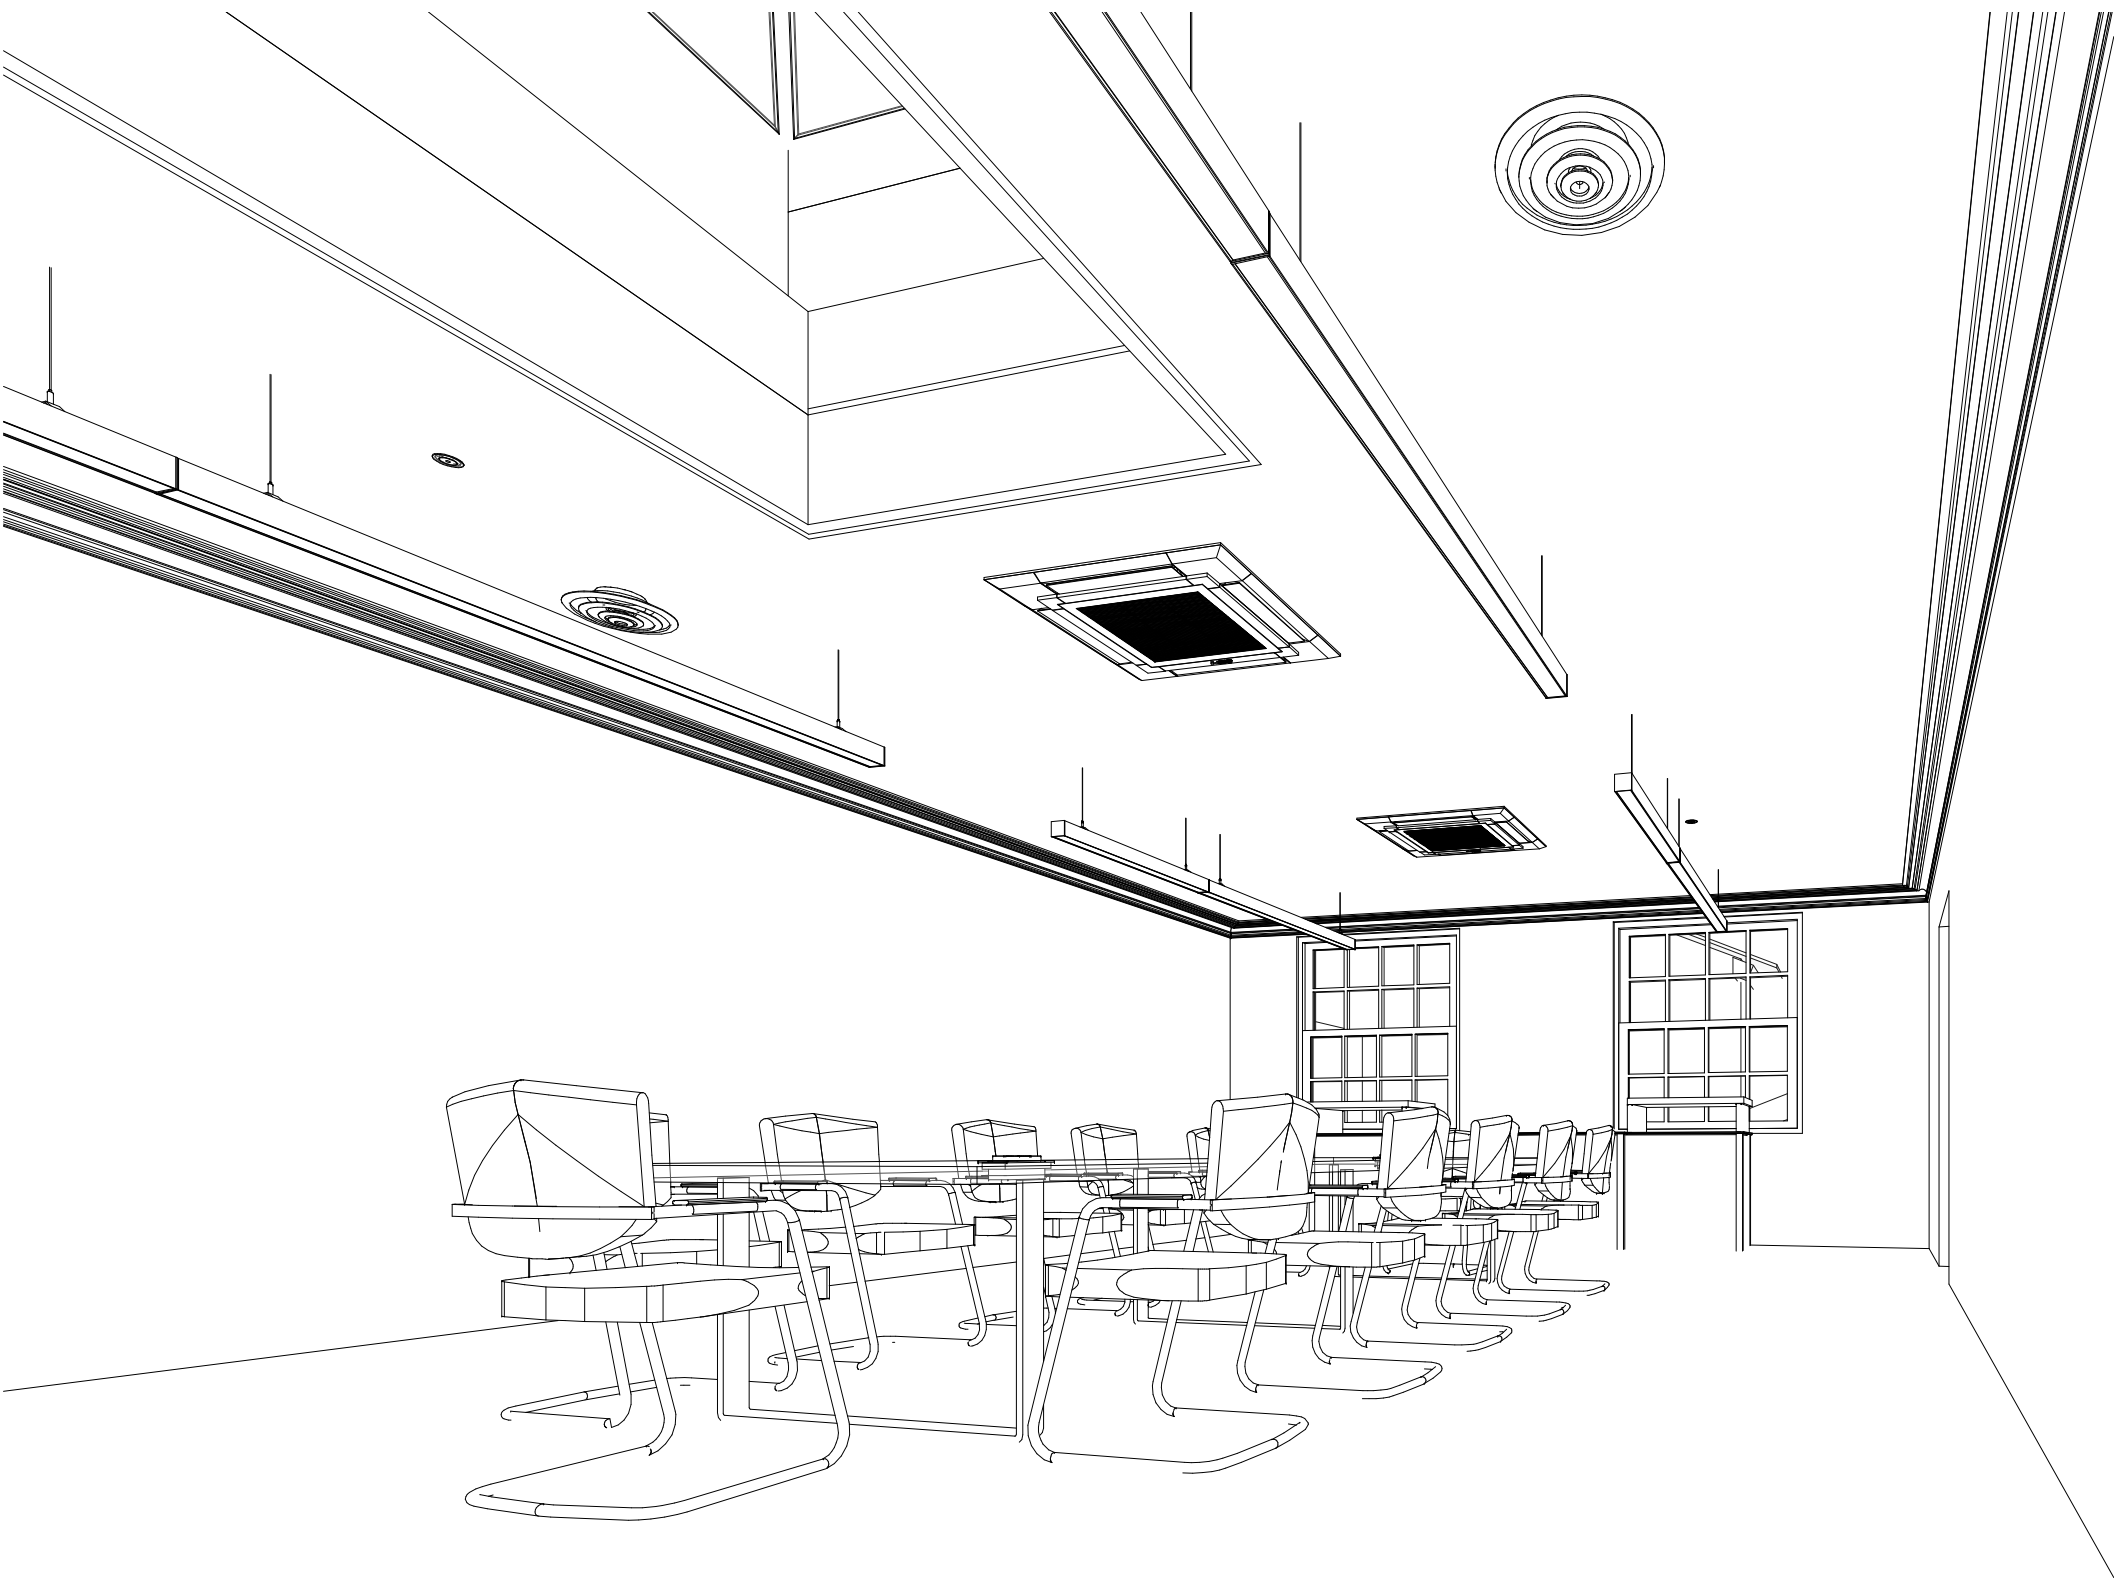

Perspective View
scale NTS@A1

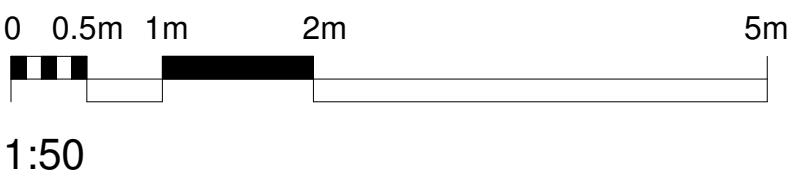

Rev	Description	Date	Dr	App
original by	date created	14.12.2022	by	approved by
ASN			JW	

AHR
AHR Building Consultancy Ltd
5th Floor
55 Princess Street
Manchester
M2 4EW
United Kingdom

T +44(0)161 8287900
E manchester@ahr.co.uk
www.ahr.co.uk

client name
High Peak Borough Council
working for our community

project
Glossop Town Hall Refurbishment

drawing
Proposed Lighting Court Room 3

computer file
H:\6C\MAN\2021\2021.00039.001 - High Peak Council - Glossop Town Hall Refurbishment\07 Design Review\0702_Construction\2021.00039.001 - High Peak Council - Glossop Town Hall Refurbishment_Construction_18.11.22.rvt

plot date

project number
2021.00039.001

scale
As indicated@A1

drawing number
SK_63-004

rev
Sketch

This drawing is to be read in conjunction with all related drawings. All dimensions must be checked and verified on site before commencing any work or producing shop drawings. The originator should be notified immediately of any discrepancy. This drawing is copyright and remains the property of AHR.