

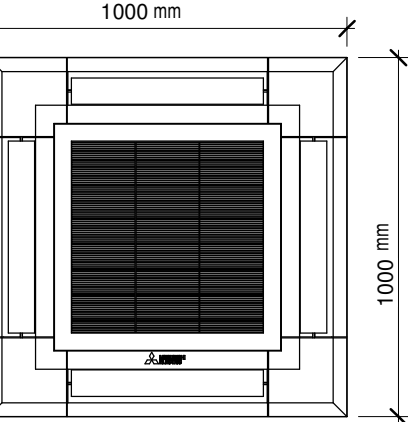


Notes

Ⓢ
THORLUX lighting - Firefly
Emergency Recessed Light

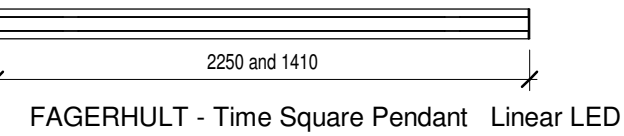

Air Conditioning Unit
4 way Casette

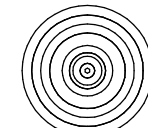


Supply / Extract Grill




Thorlux Firefly recessed emergency light





Fagerhult Time square pendant light

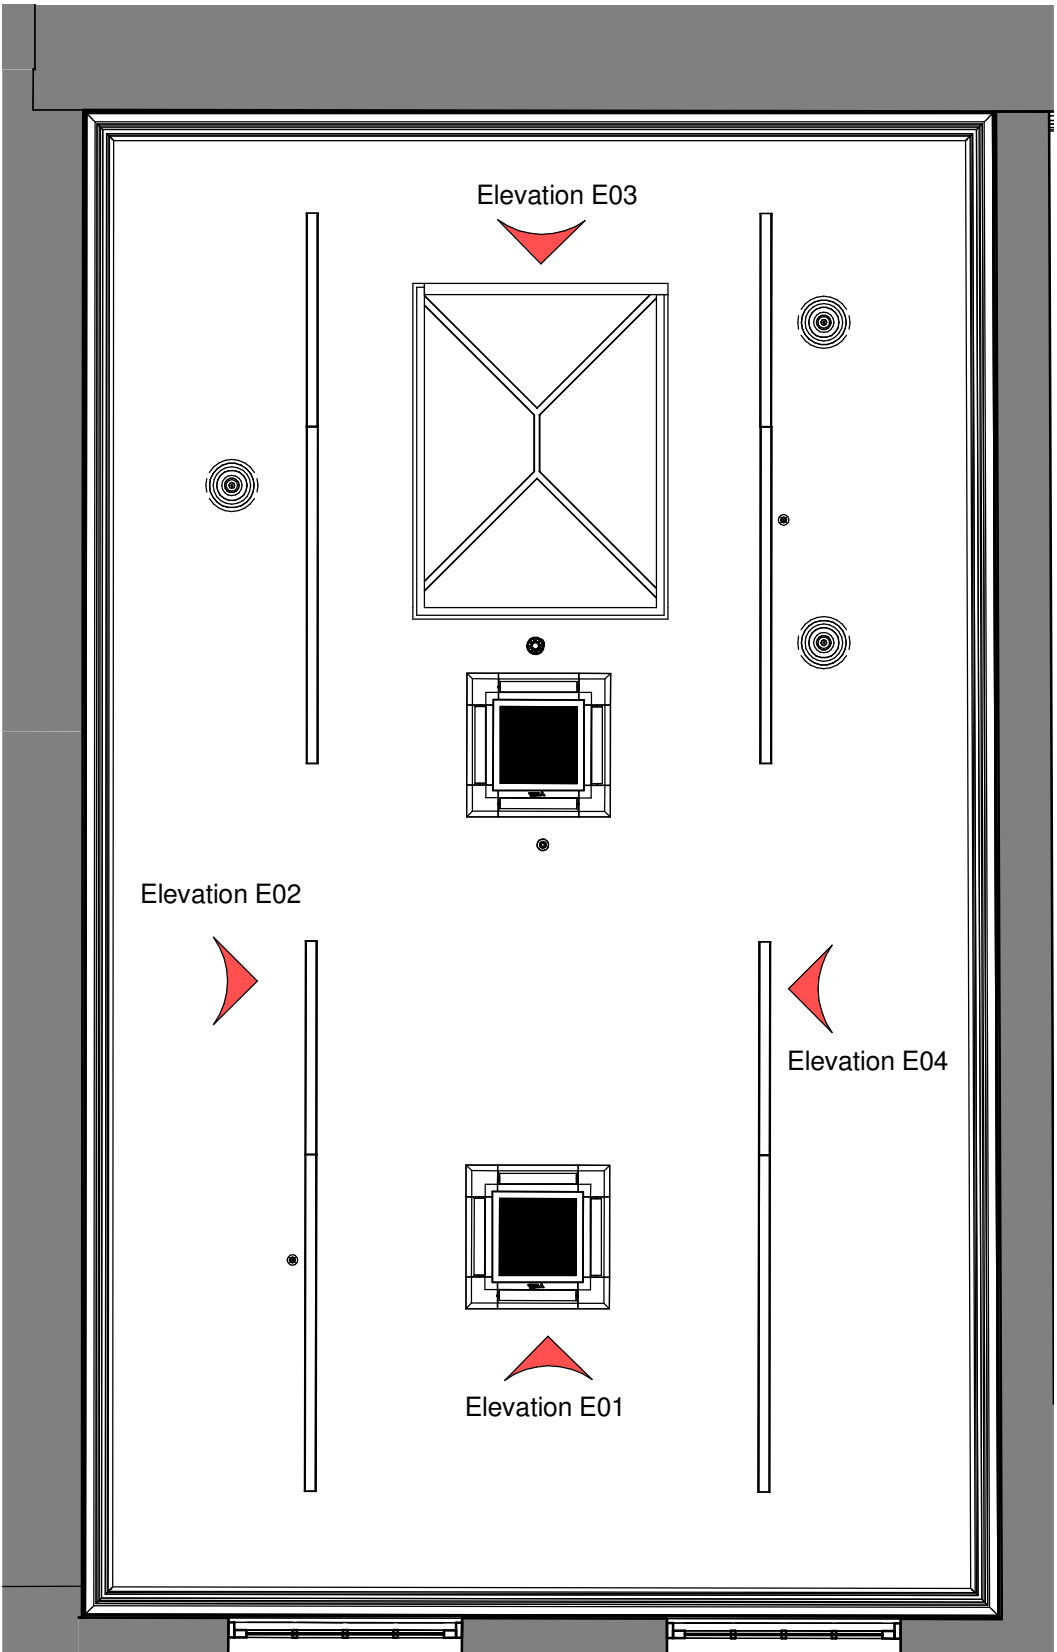


Court Room 3 Reflected Ceiling Plan
scale 1:50@A1

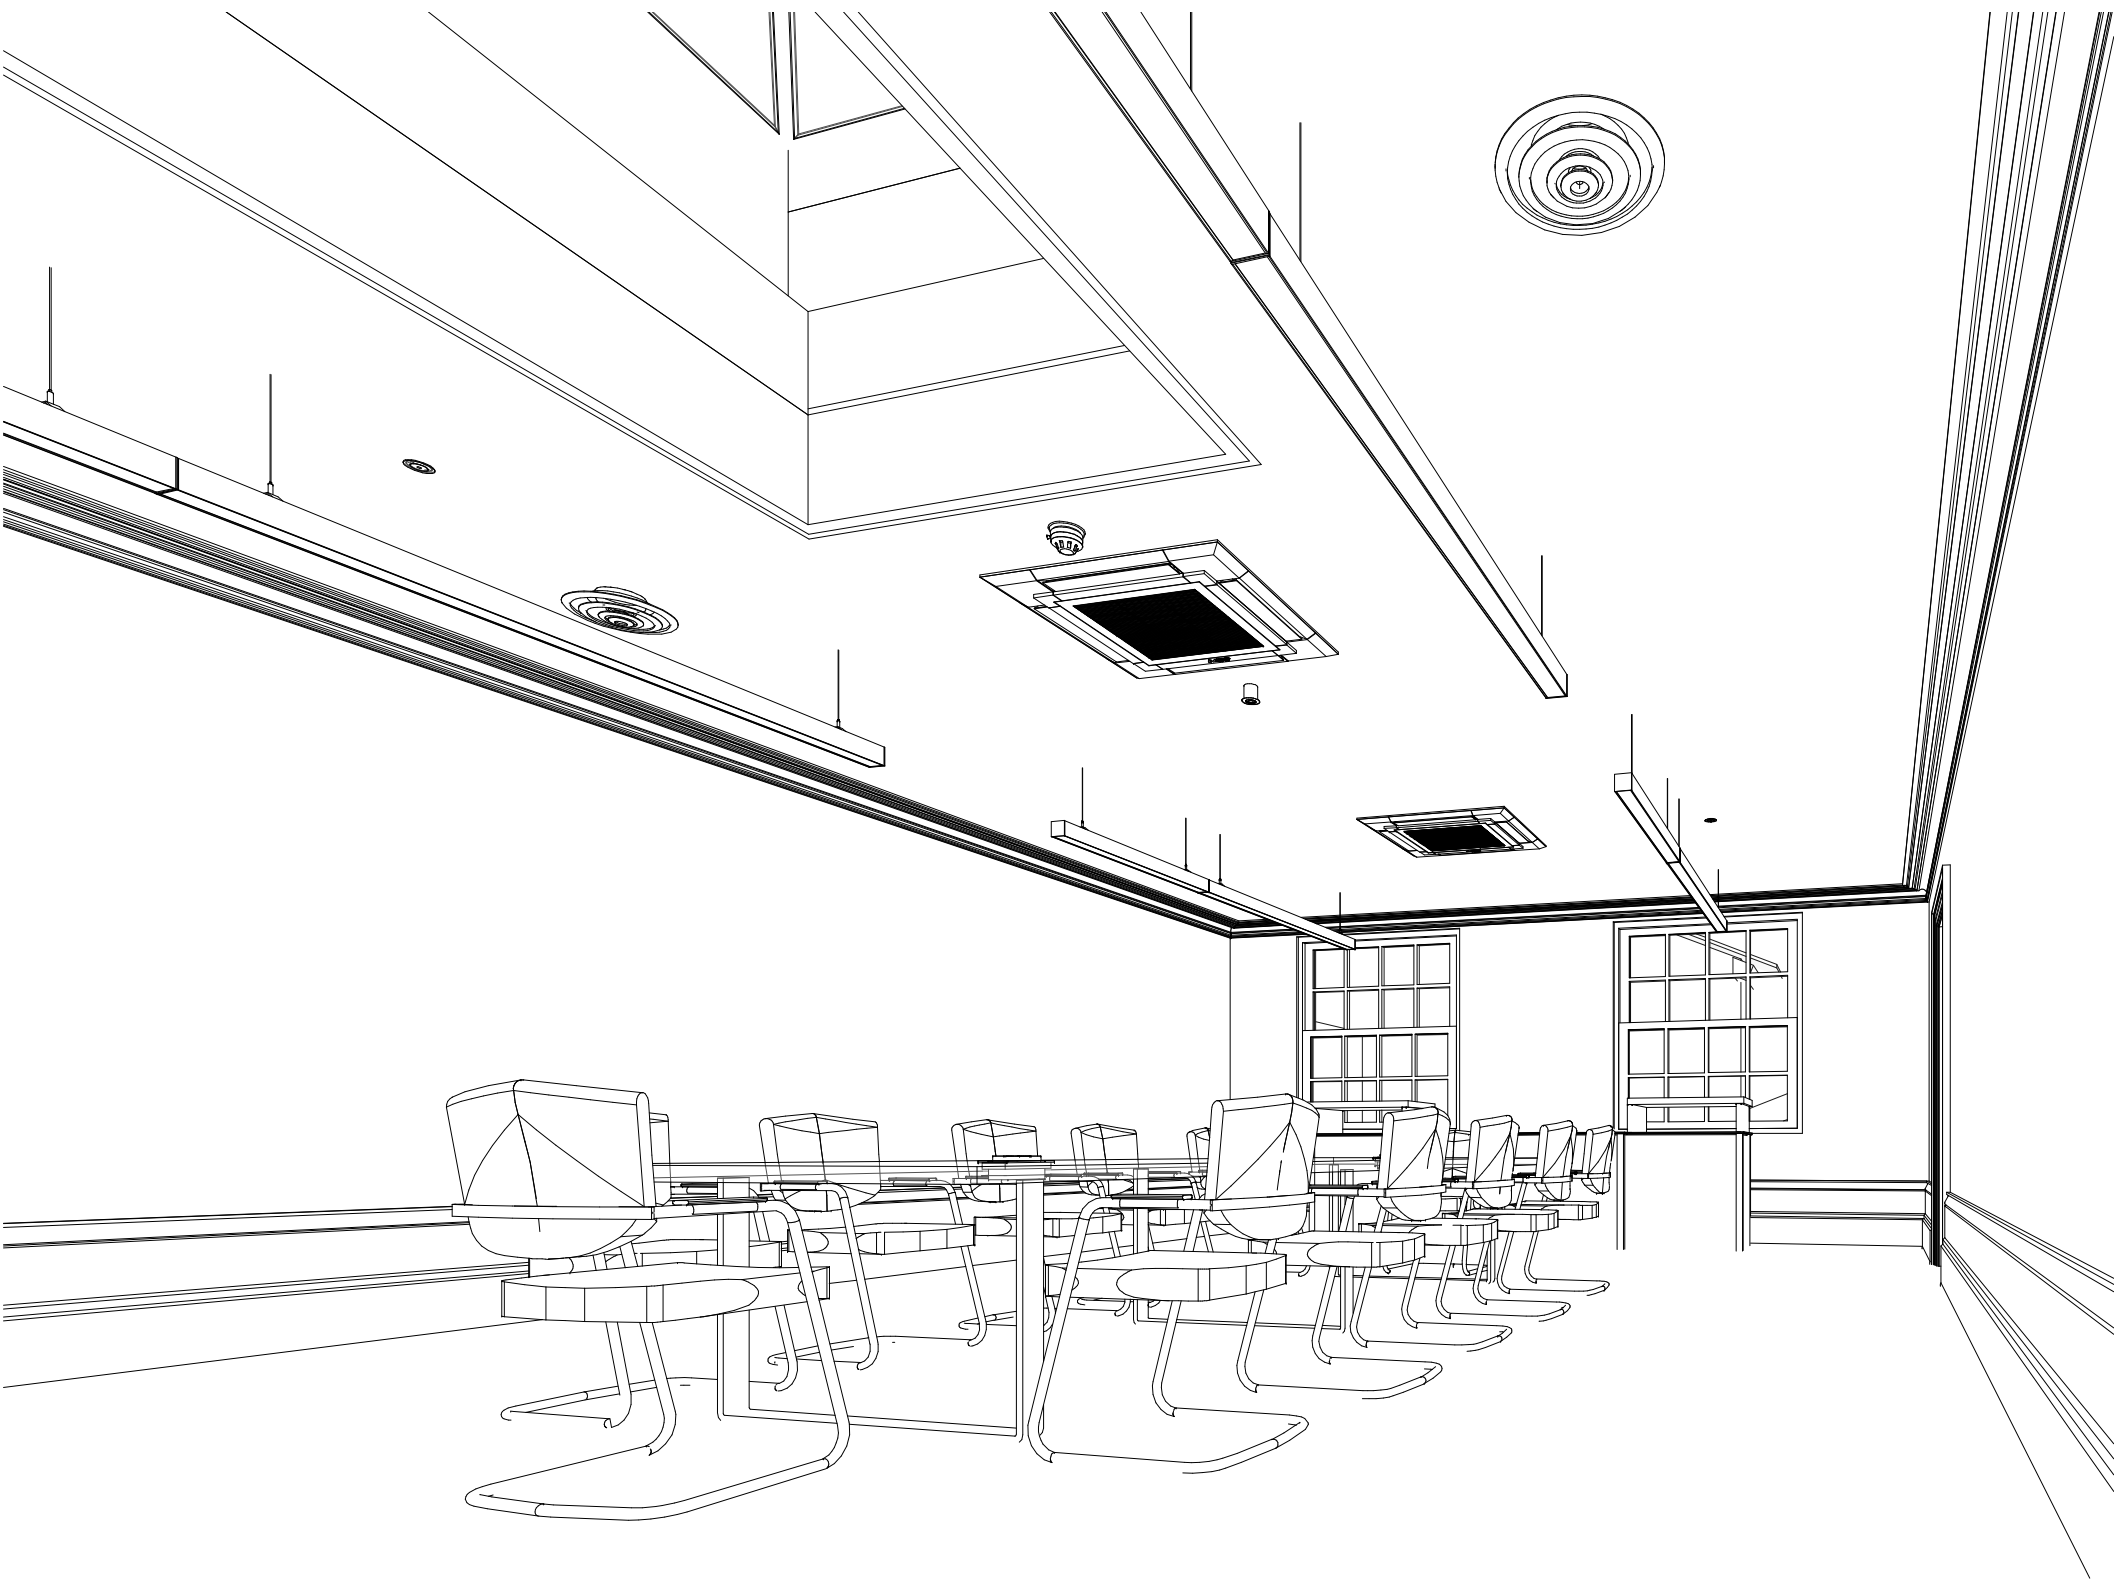


Perspective View
scale NTS@A1

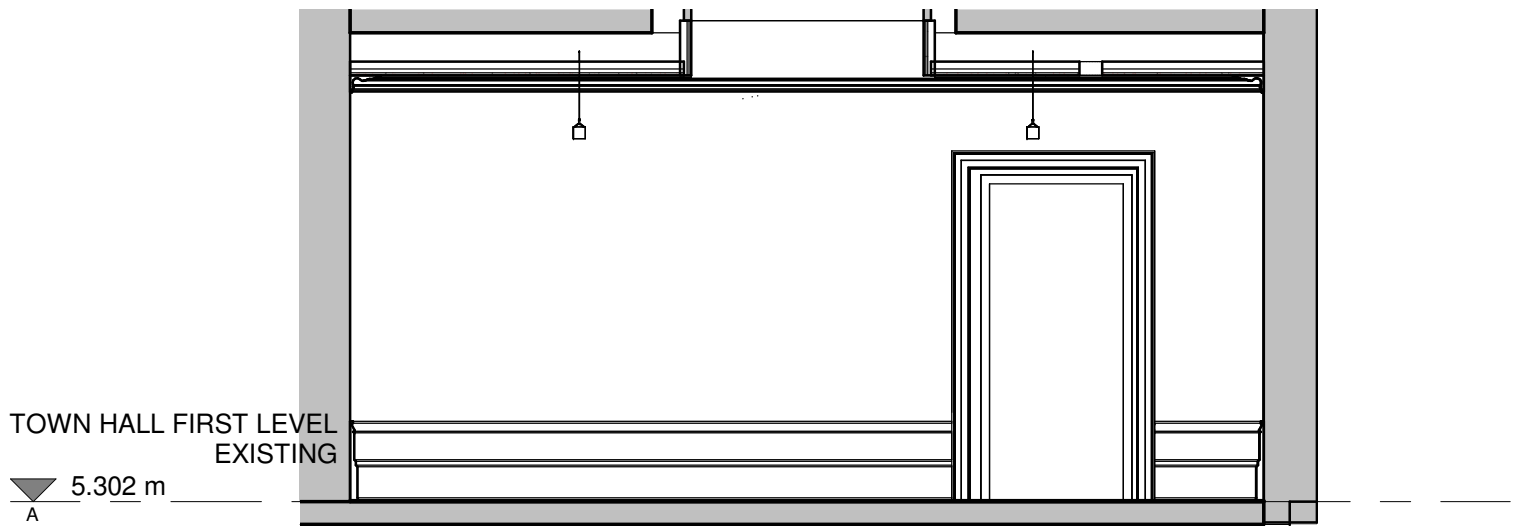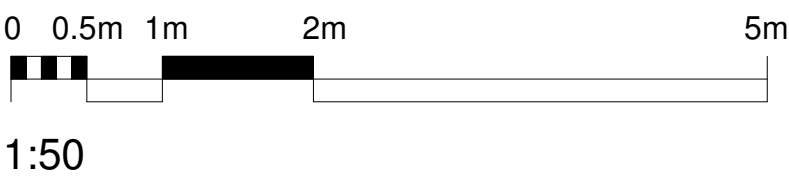


Internal Elevation E01
scale 1:50@A1

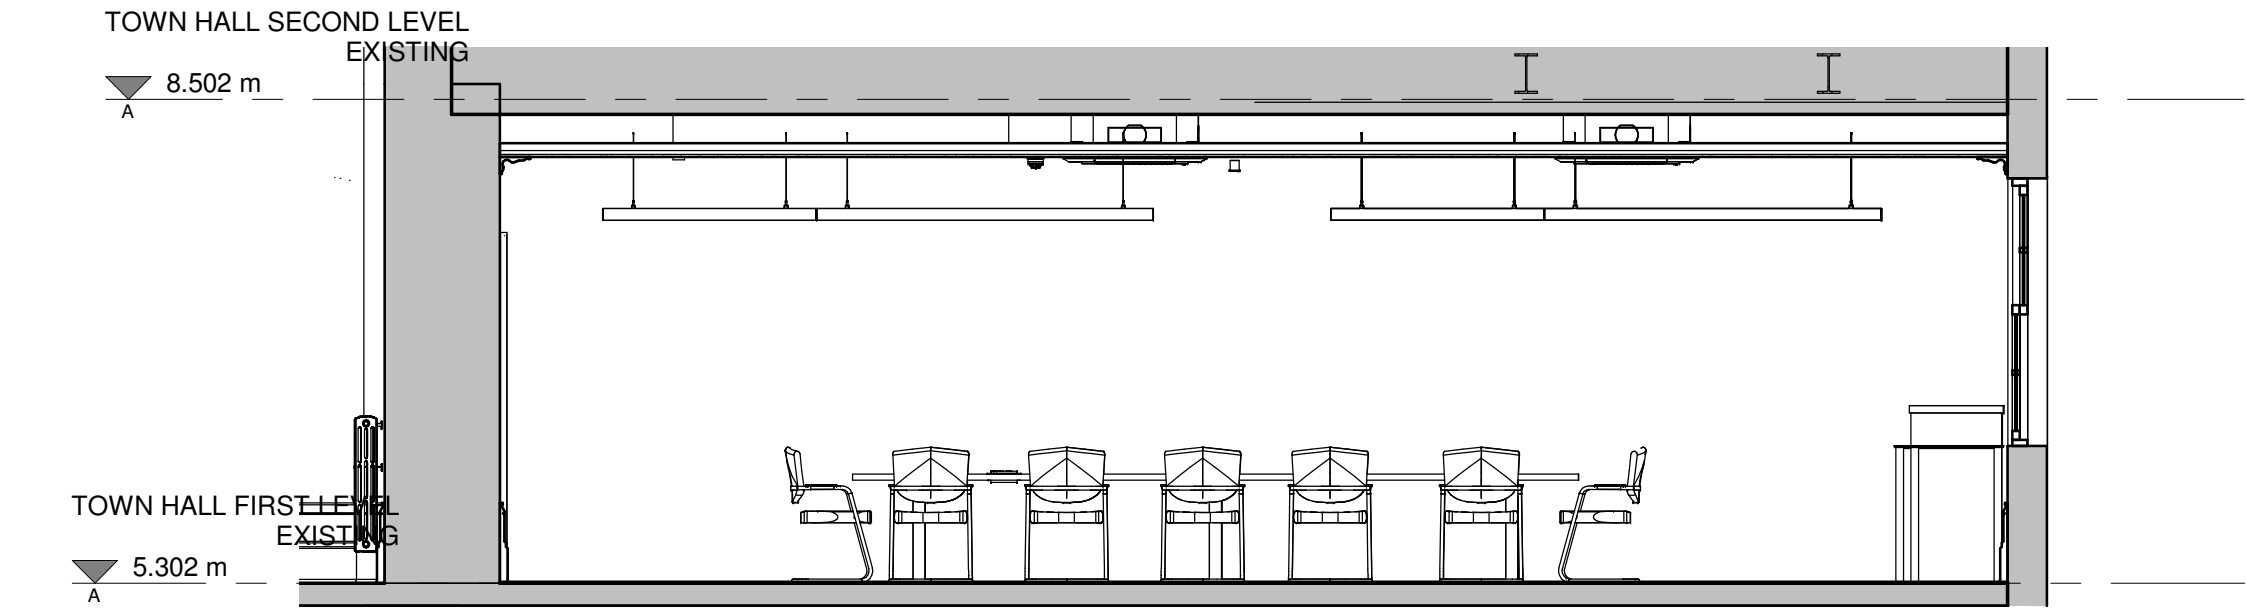

Internal Elevation E02
scale 1:50@A1

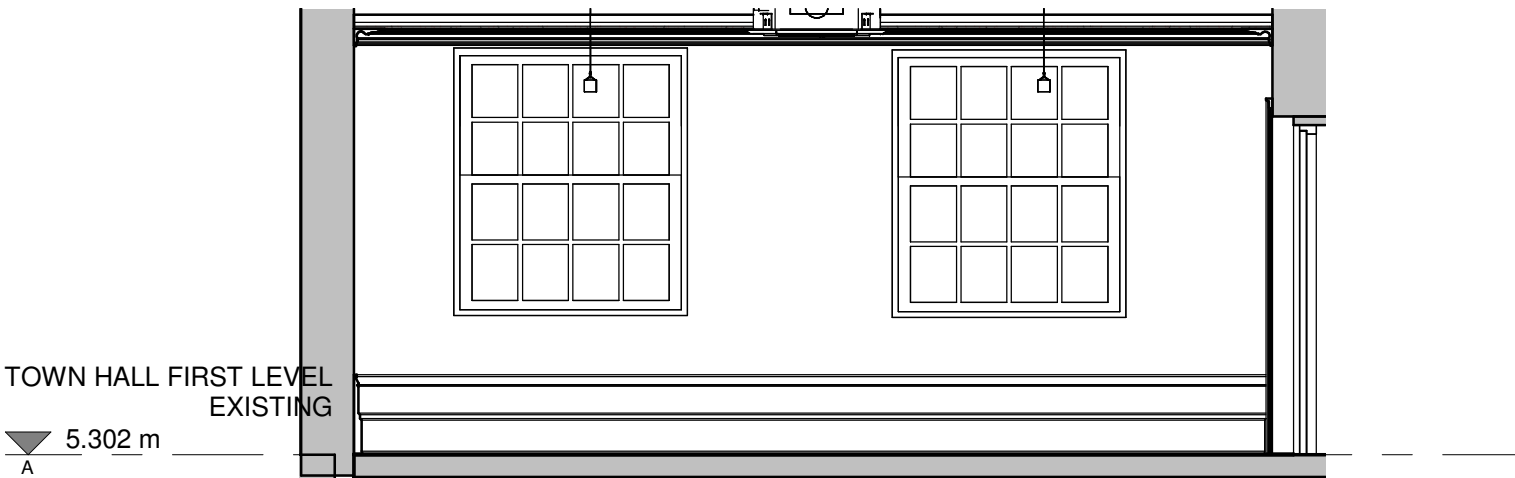

Internal Elevation E03
scale 1:50@A1

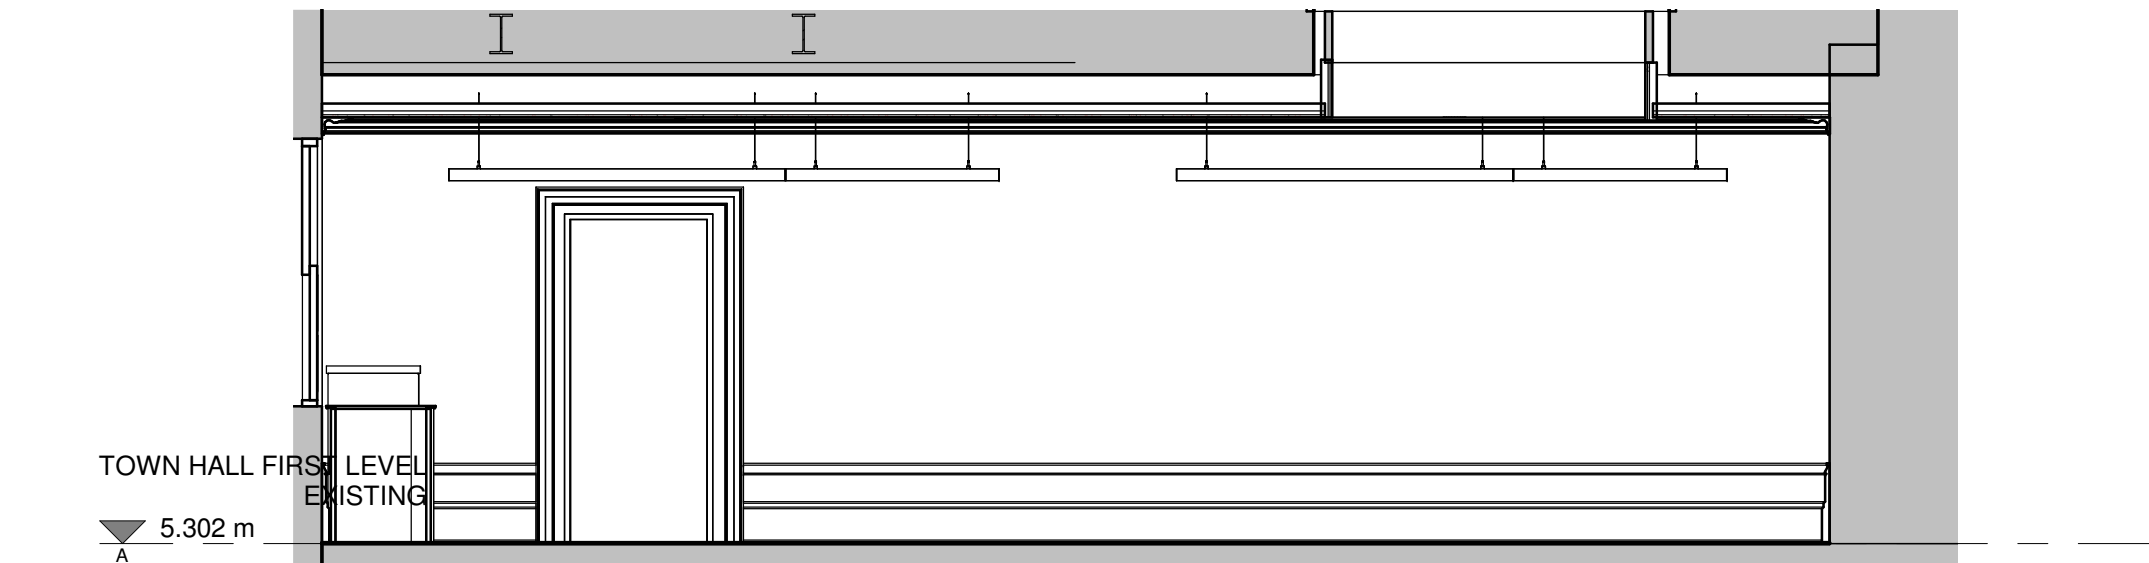

Internal Elevation E04
scale 1:50@A1

A	Ventilation Diffuser Updated	06.07.23	ASN	JW
Rev	Description	Date	Dr	App
original by	ASN	date created	by	by
		14.12.2022	JW	approved by

AHR
AHR Building Consultancy Ltd
5th Floor
55 Princess Street
Manchester
M2 4EW
United Kingdom

T +44(0)161 8287900
E manchester@ahr.co.uk
www.ahr.co.uk

client name	 High Peak Borough Council <i>working for our community</i>		
project	Glossop Town Hall Refurbishment		
drawing	Proposed Lighting Court Room 3		
computer file	C:\Users\alan.nutall\REVIT\LOCAL FILES\2021\00039\001 - High Peak Council - Glossop Town Hall Refurbishment Construction-18.11.22_alan.nutall\PM\MC.rvt		plot date
project number	2021.00039.001		scale
drawing number	SK_63-004		As indicated@A1
	rev	issue status	
	A	Sketch	

This drawing is to be read in conjunction with all related drawings. All dimensions must be checked and verified on site before commencing any work or producing shop drawings. The originator should be notified immediately of any discrepancy. This drawing is copyright and remains the property of AHR.