
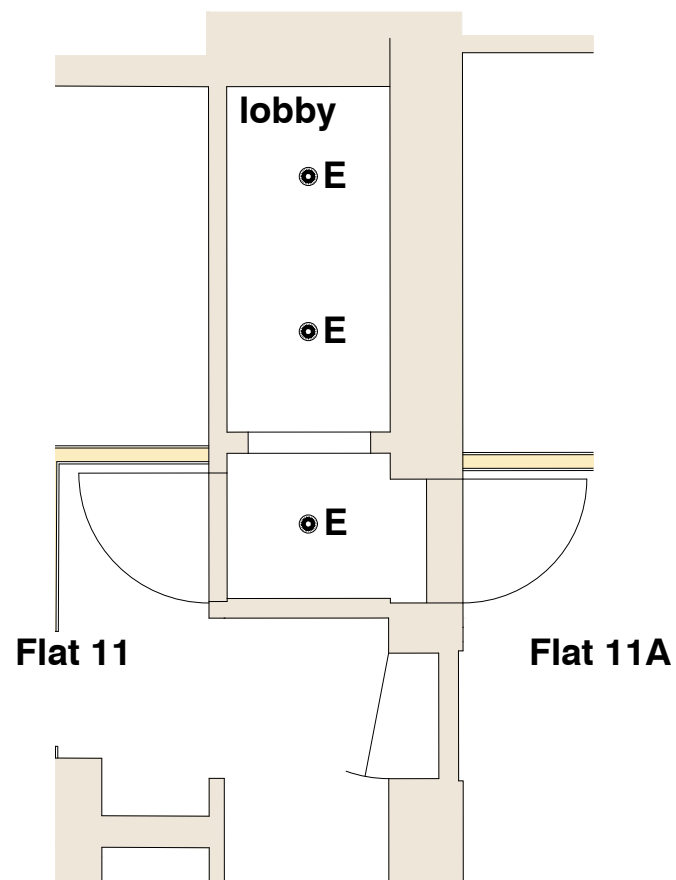
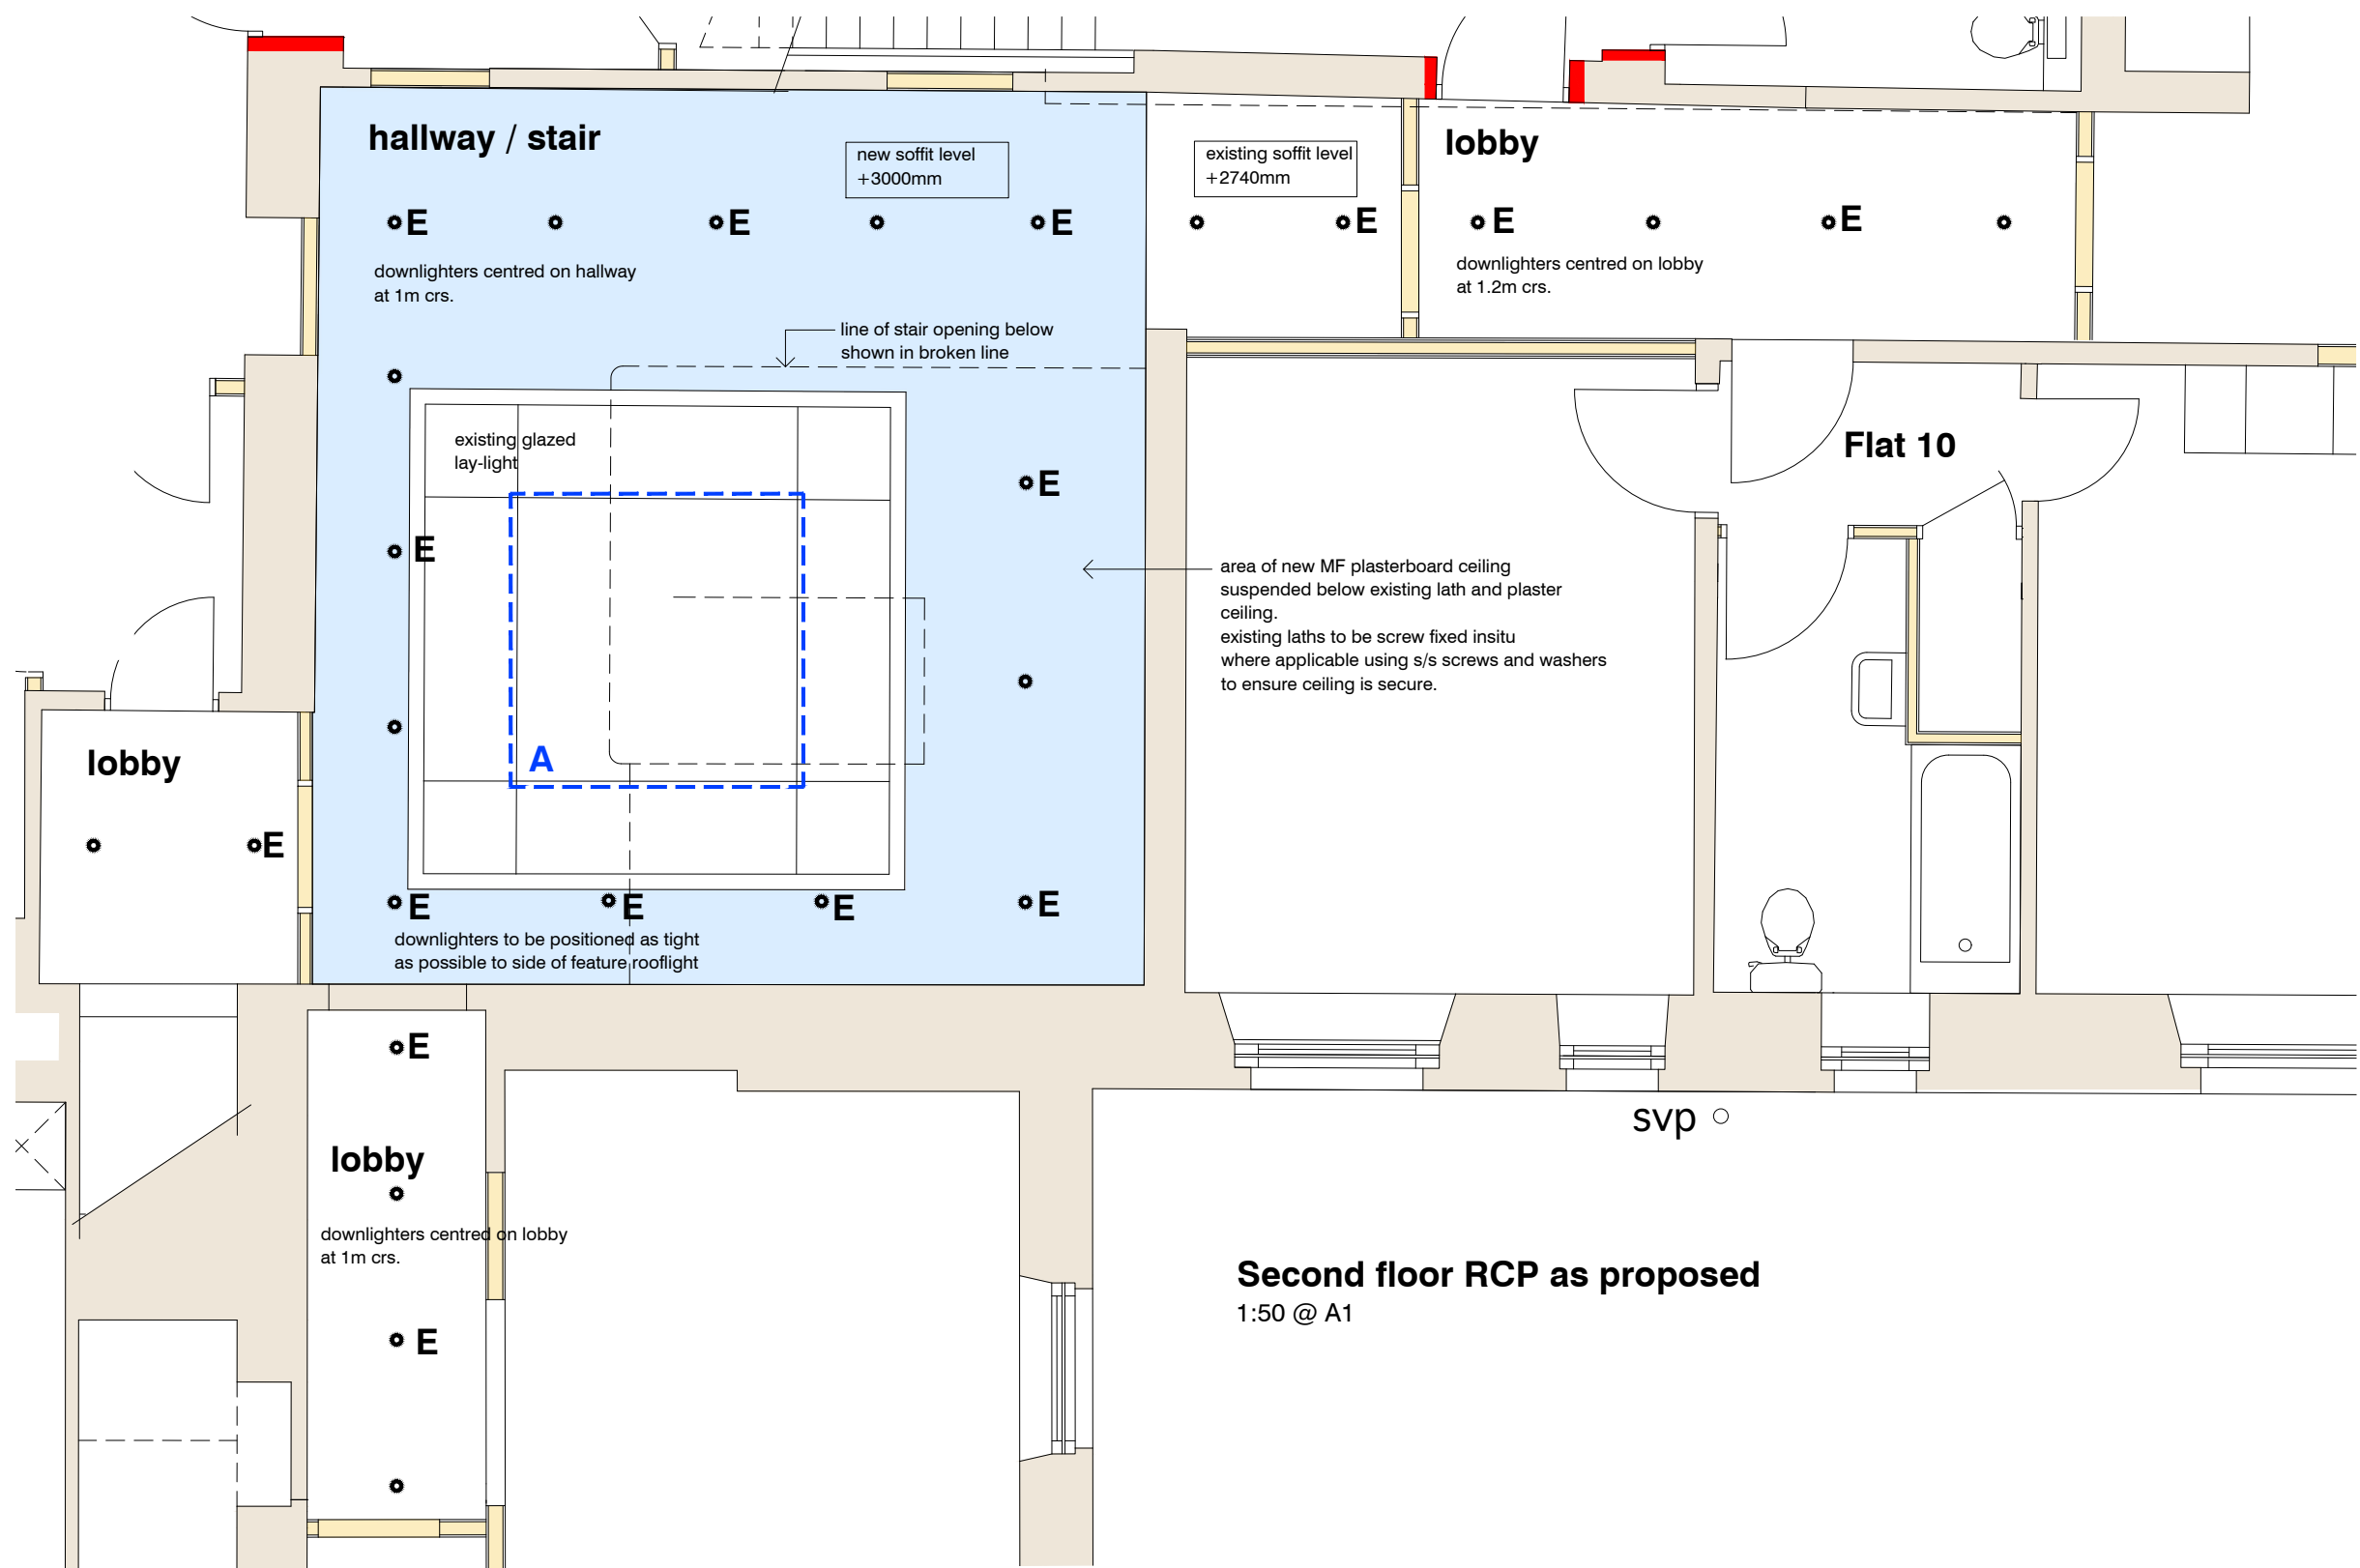
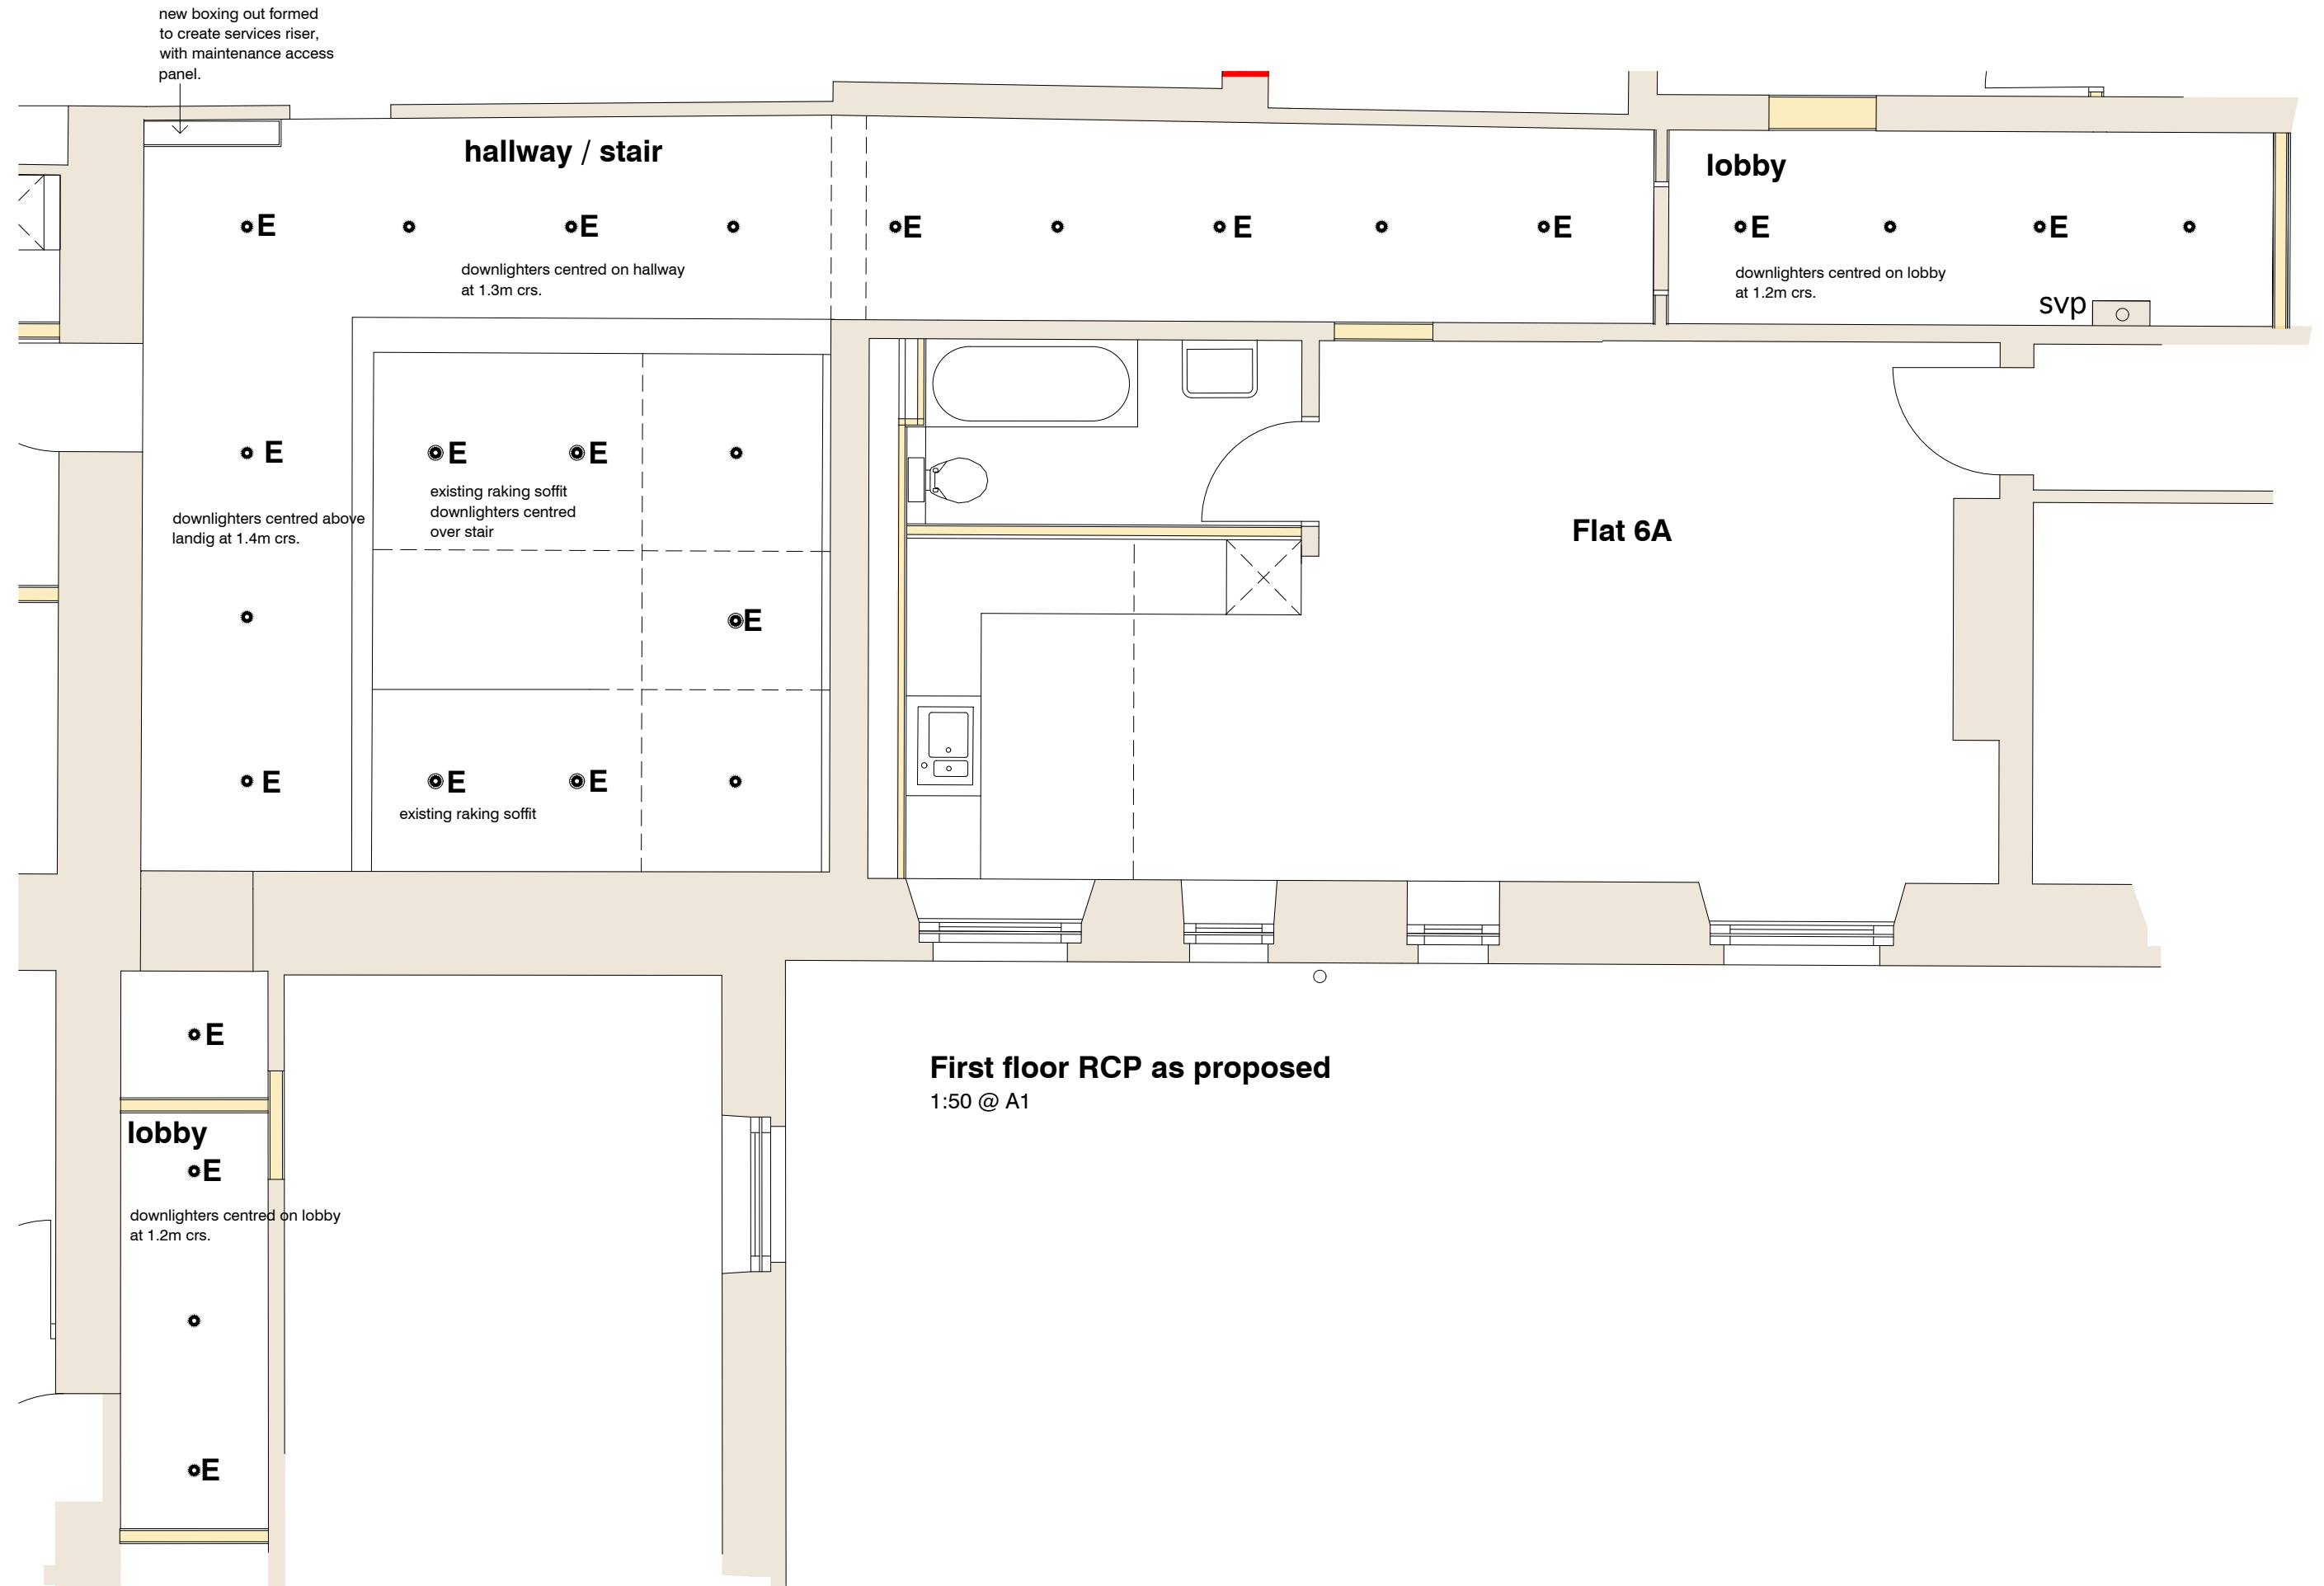


All sizes to be checked on site prior to construction.
This drawing is the copyright of the author.

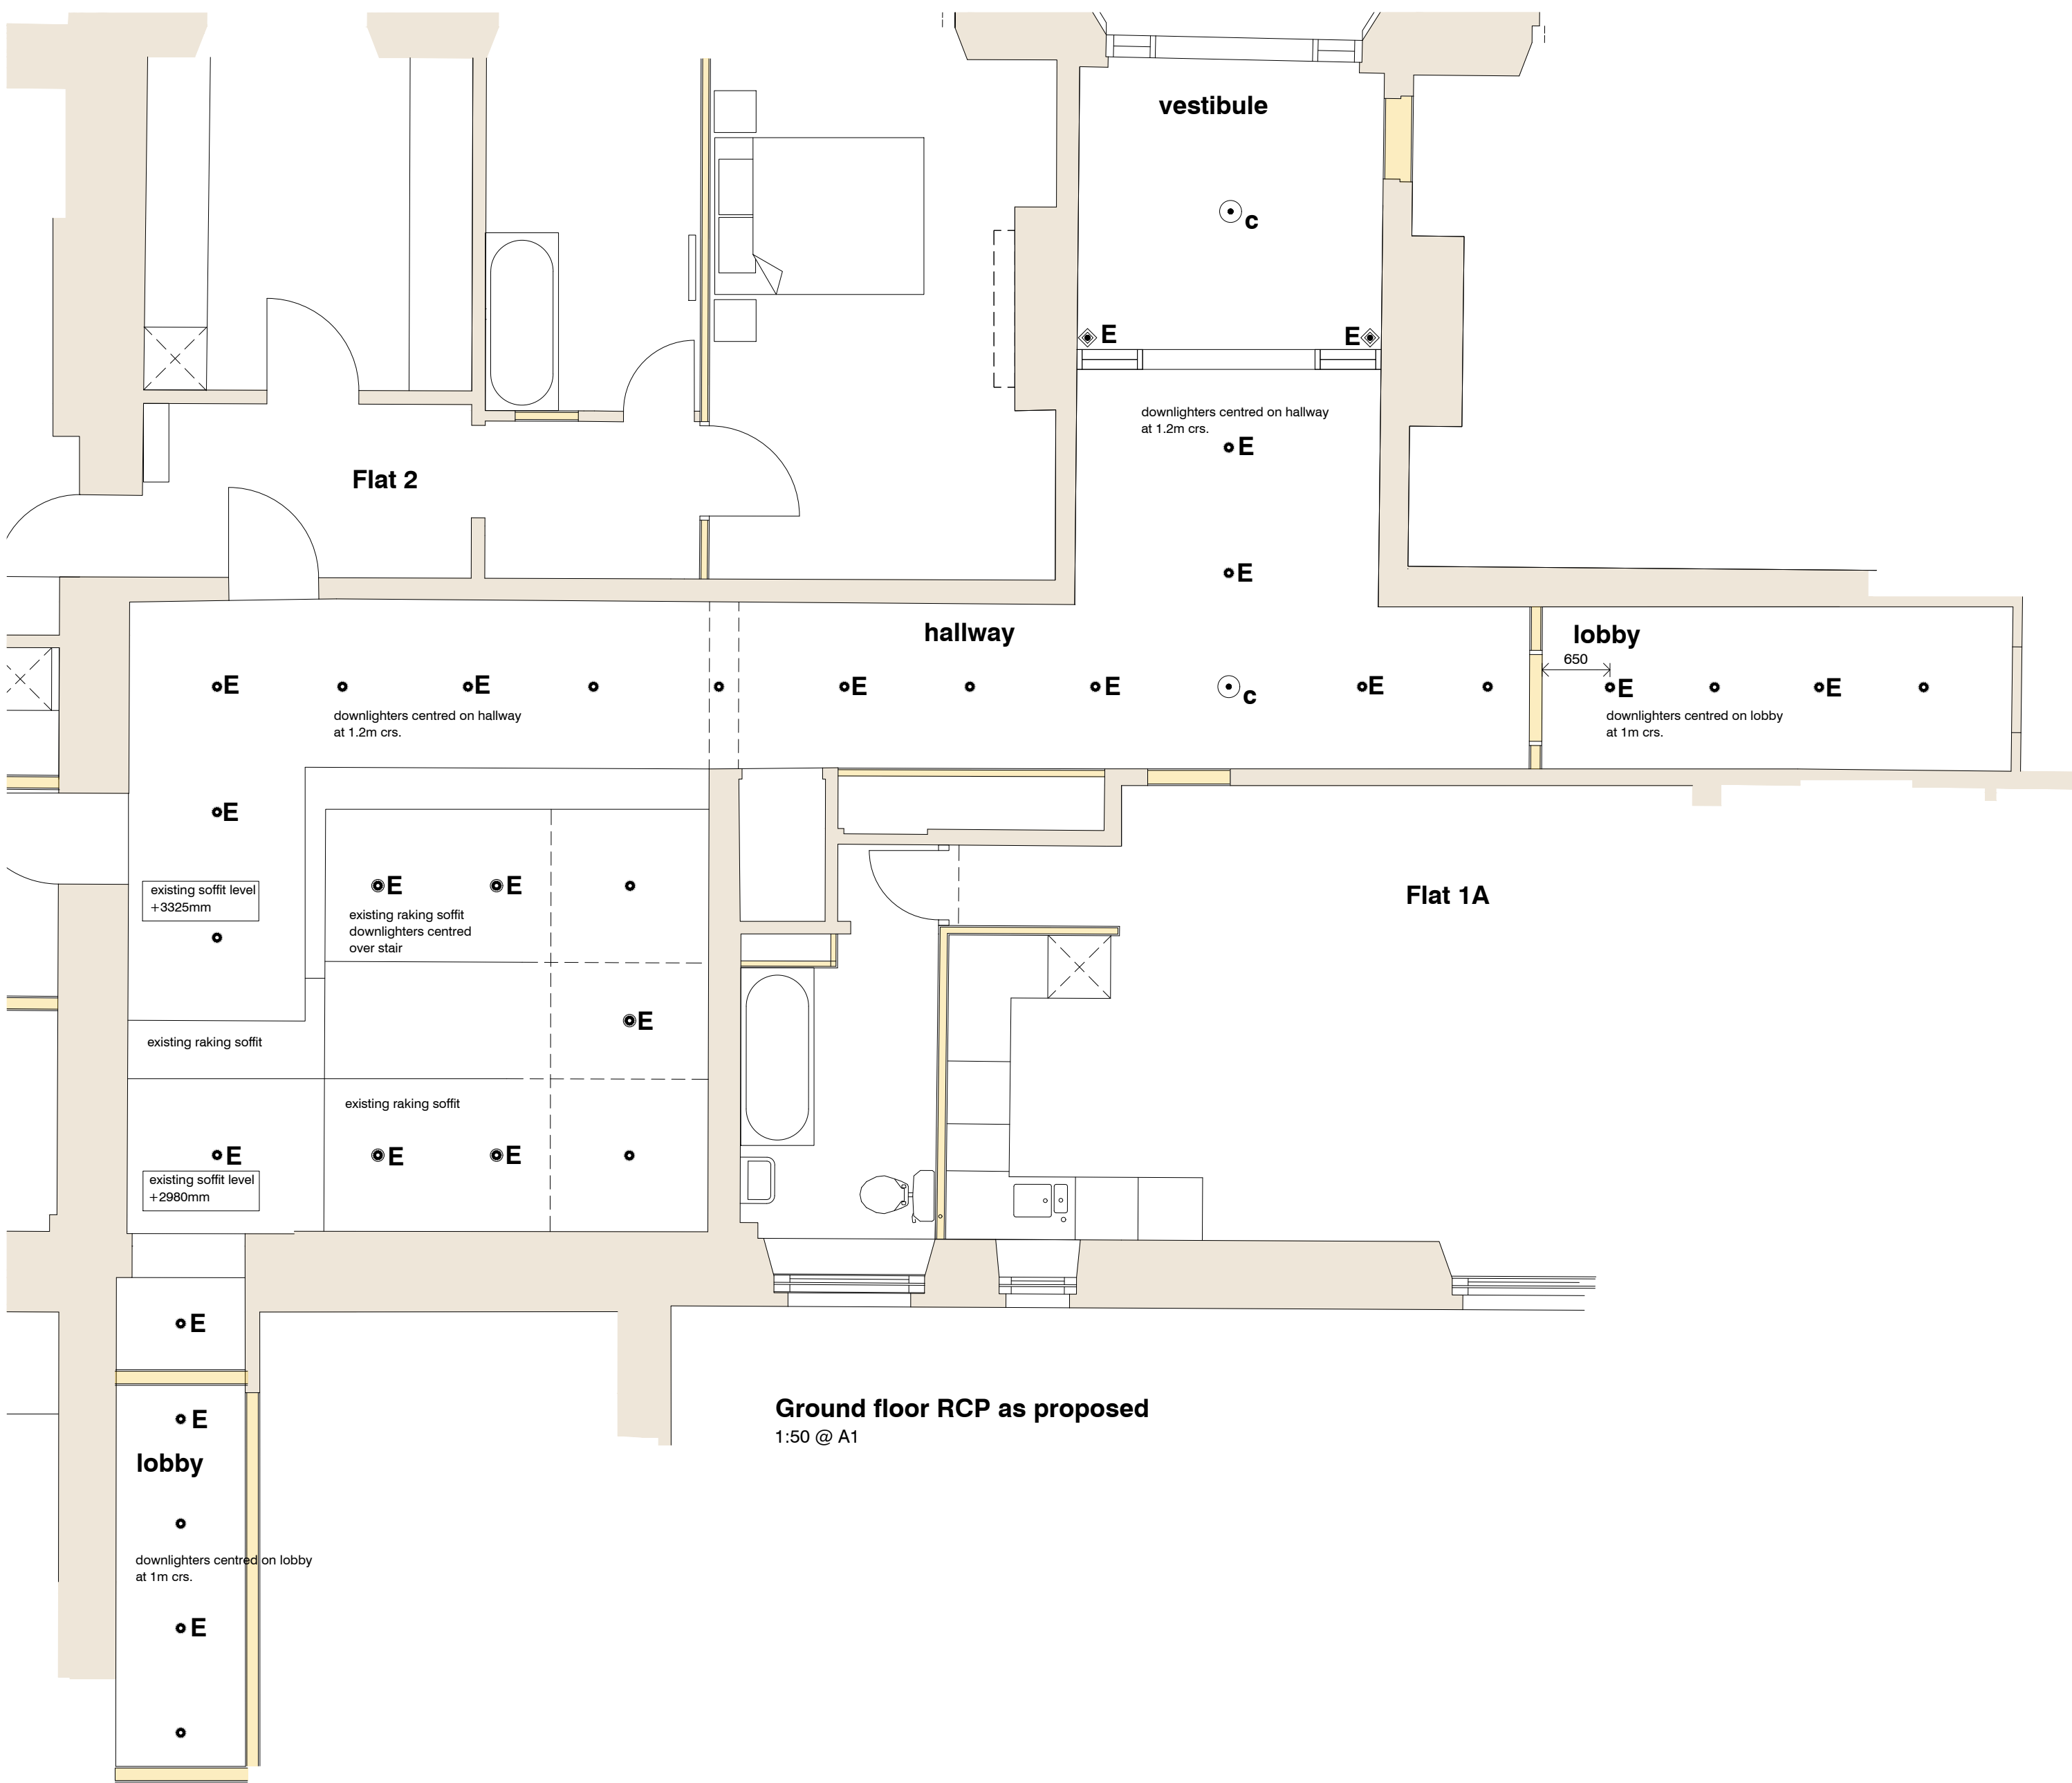

Lighting Key

- c chandelier
- ◆ E emergency spotlights to illuminate vestibule space.
non-maintained supply, to operate in event of power failure.
- integrated LED downlights in warm white.
'E' denotes emergency fitting from same range.
emergency fittings to be maintained.
- ⦿ integrated tilting LED downlights in warm white.
'E' denotes emergency fitting from same range.
emergency fittings to be maintained.
- A LED strip light (on separate circuit) positioned above
existing glazed lay light

all lighting controlled on PIR detectors.

rev. date details drawn
A 03.08.23 lighting details added sh



scott hammond design
architecture + design
The Hive, 1069 Argyle Street, Glasgow G3 8LZ
07938 531868
mail@hammondsgn.co.uk

client	George Mansions Buxton Ltd.		
project	Refurbishment of George Mansions St John's Road, Buxton		
drawing	Common Area Reflected Ceiling Plans	original size	A1
scale	1:50	drawn	sh
date	May 2023	checked	
status	information	passed	
job no.	SHD059	drawing no.	AL(0)09
		revision	A