



Notes:


- This drawing is copyright.
- Contractors are advised to check dimensions with the architect before setting out on site.
- This drawing is to be read in conjunction with all other relevant drawings.
- All discrepancies on this drawing are to be reported to the architect.
- Do not modify any element of this drawing.
- Use drawing only for purposes issued.

Scale:
1:200 @ A3

0m 1m 2m 3m 4m 5m 10m

North

Project:	Kuranda House	Date:	May 2023
Client:	Brett Maclellan	Drawing Title:	Proposed Site Plan
Purpose:	PLANNING	Drawing number:	SP(90)03
		Revision:	2

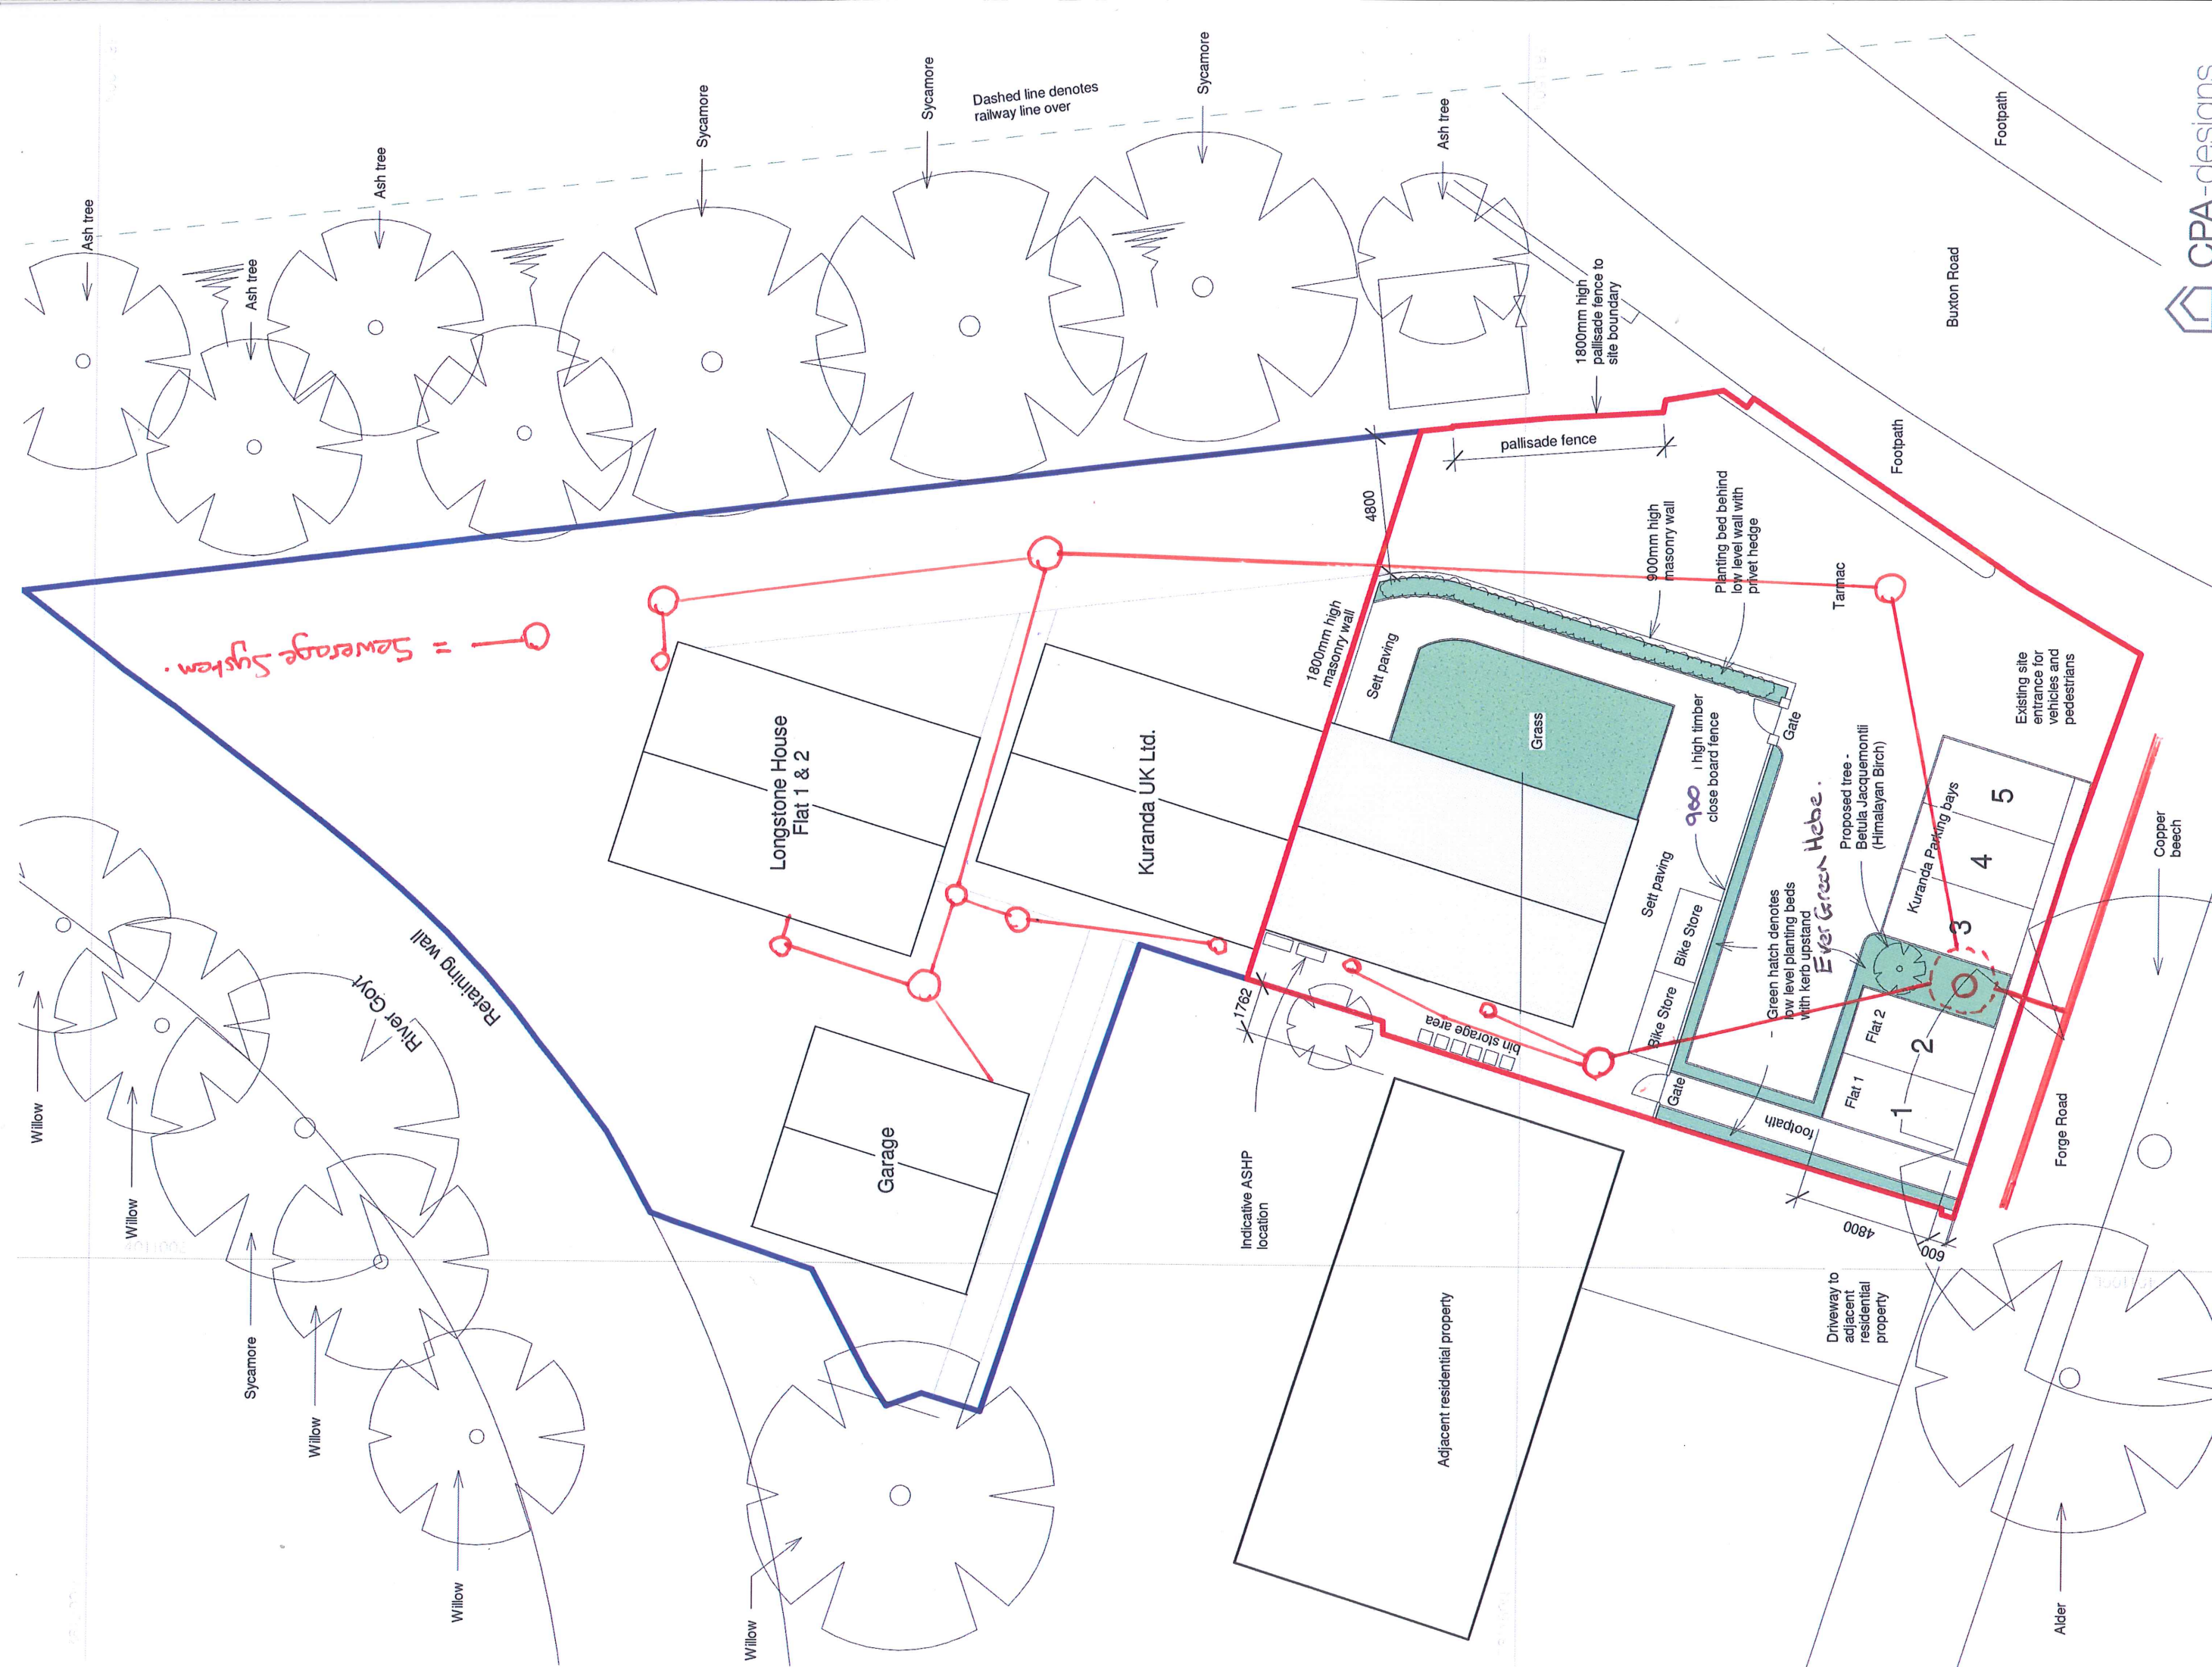

= Sewerage System.

Notes:

- This drawing is copyright.
- Contractors are advised to check dimensions with the architect before setting out on site.
- This drawing is to be read in conjunction with all other relevant drawings.
- All measurements on this drawing are to be reported to the architect.
- Do not make any amendments to this drawing.
- Use drawing only for purpose(s) issued.

Project: Kuranda House
Client: Brett McLellan
Purpose: PLANNING

Date: May 2023
Drawing Title: Proposed Site Plan
Drawing number: SP(90)03

Scale: 1:200 @ A3
Scale @ A3: 1:200

Revision: 2

CPA-designs