




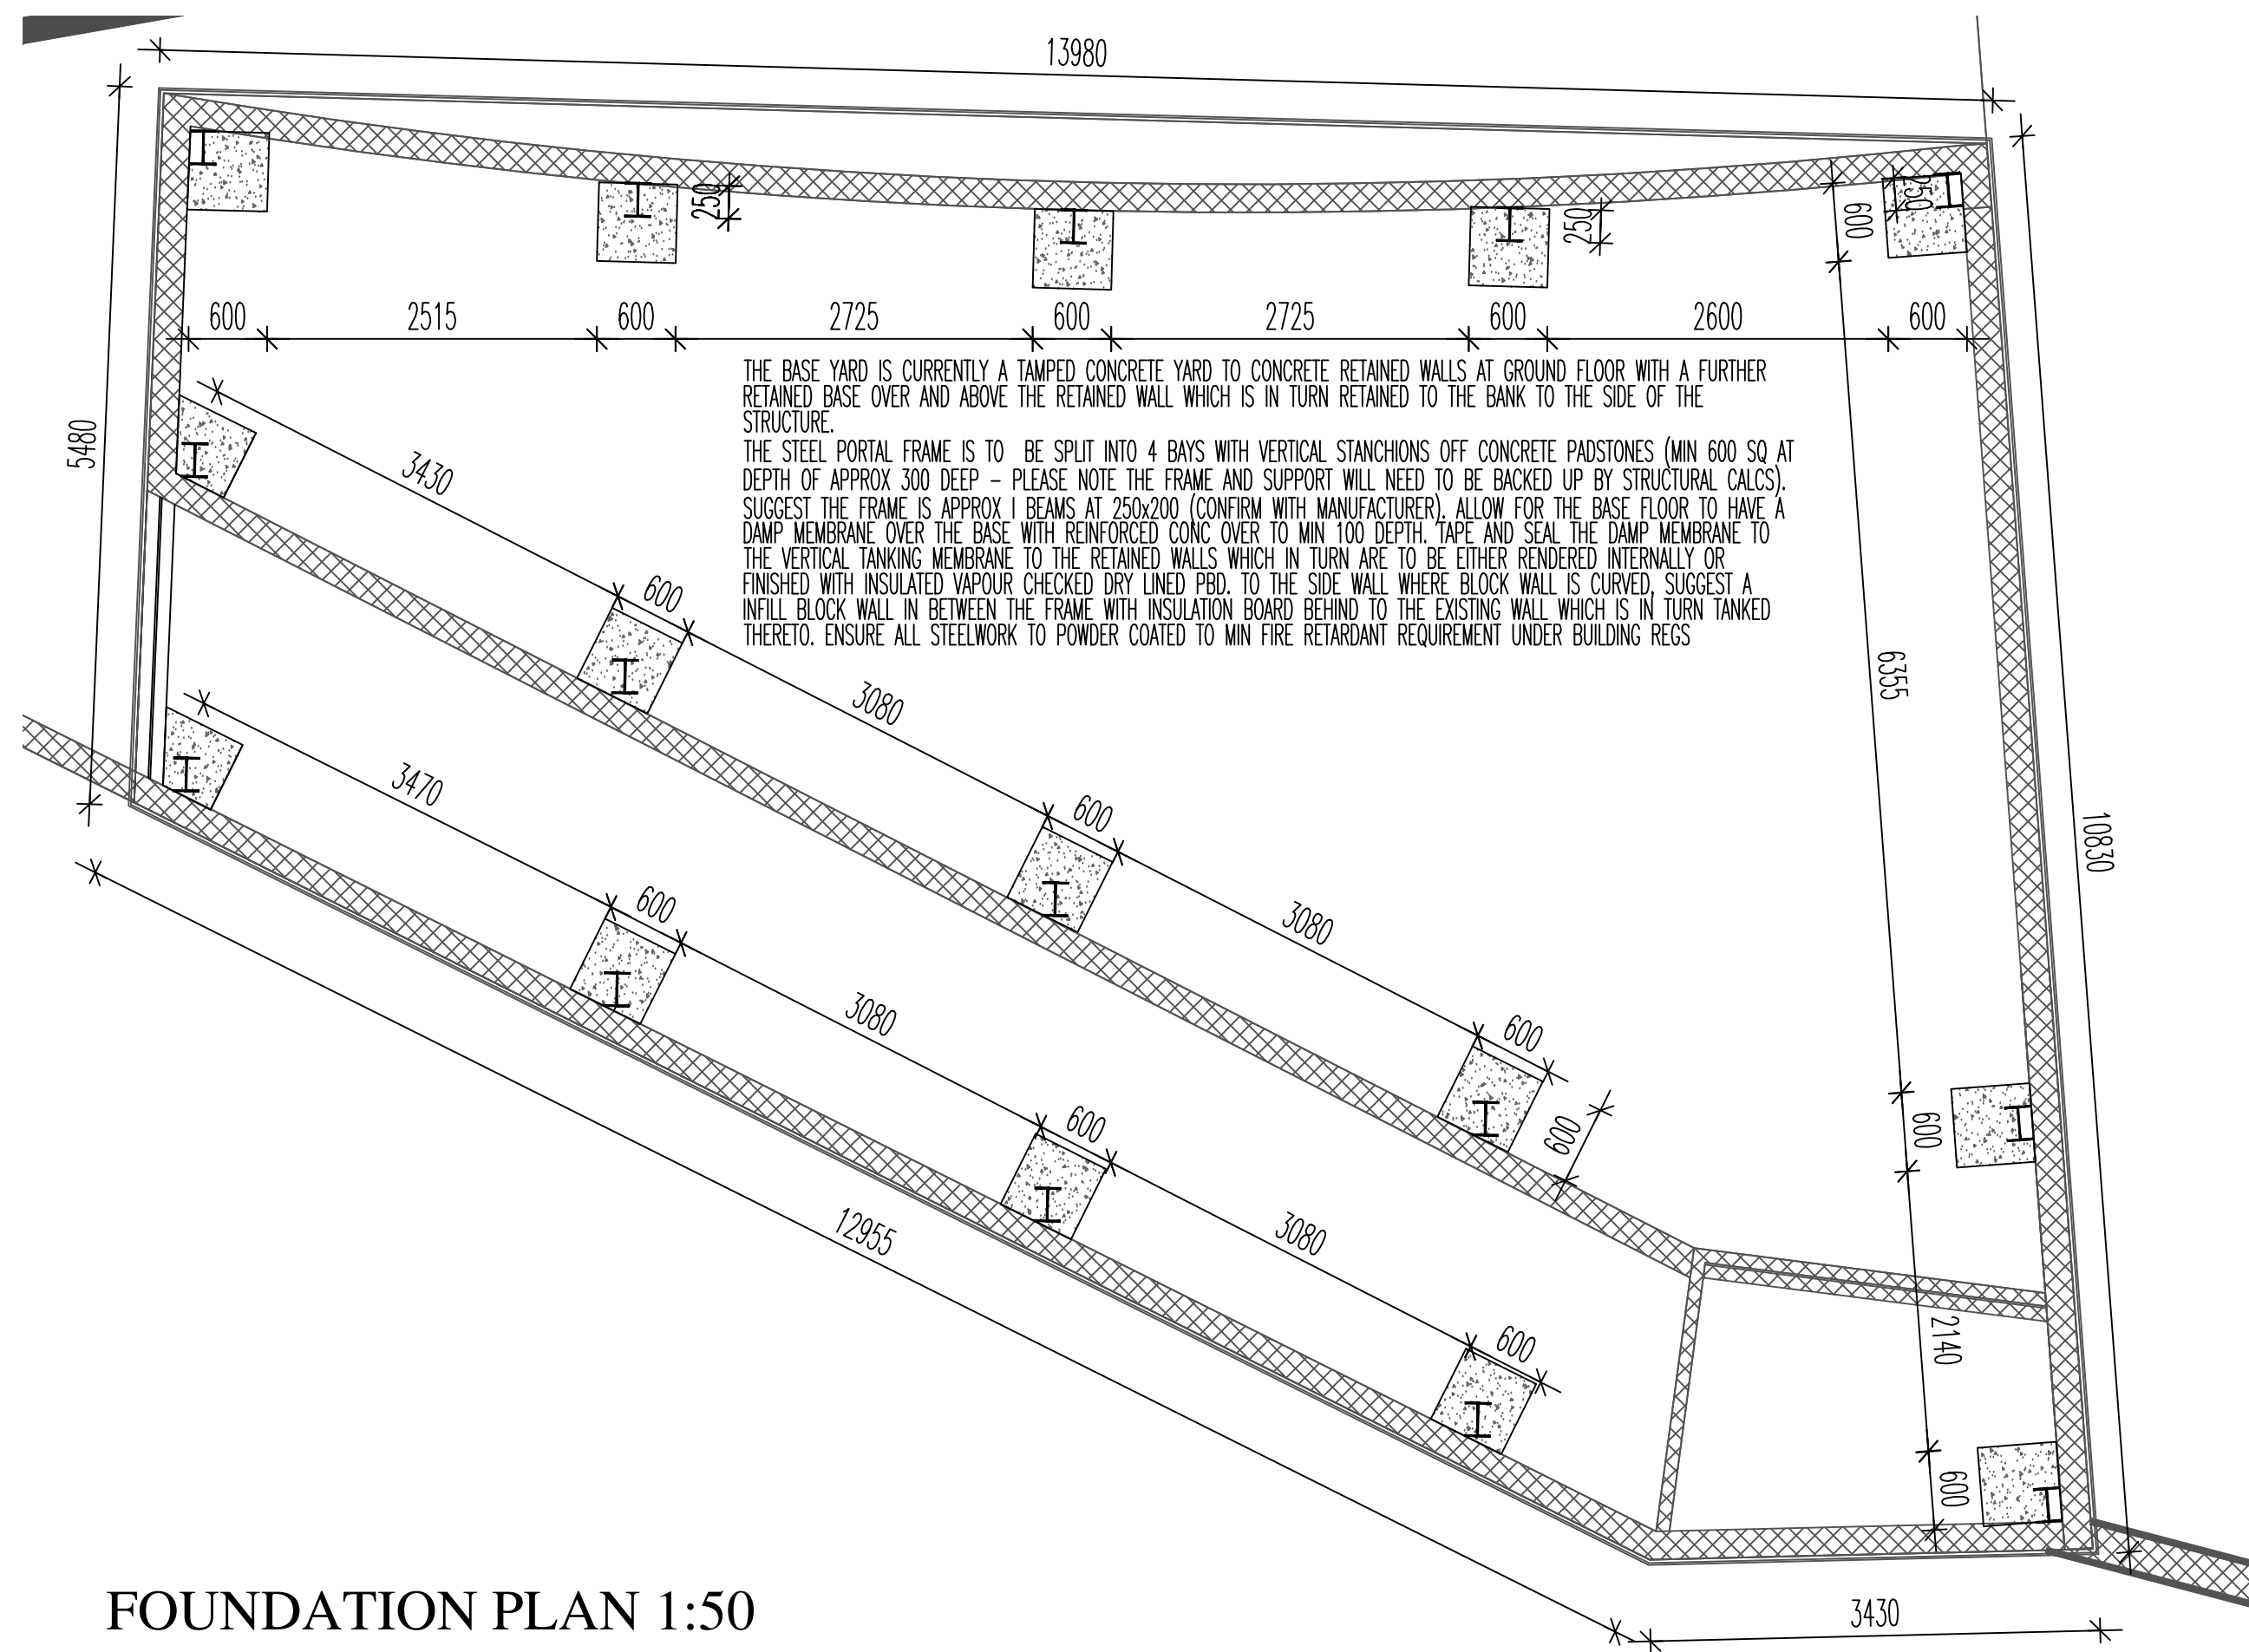


FOUNDATION PLAN 1:50

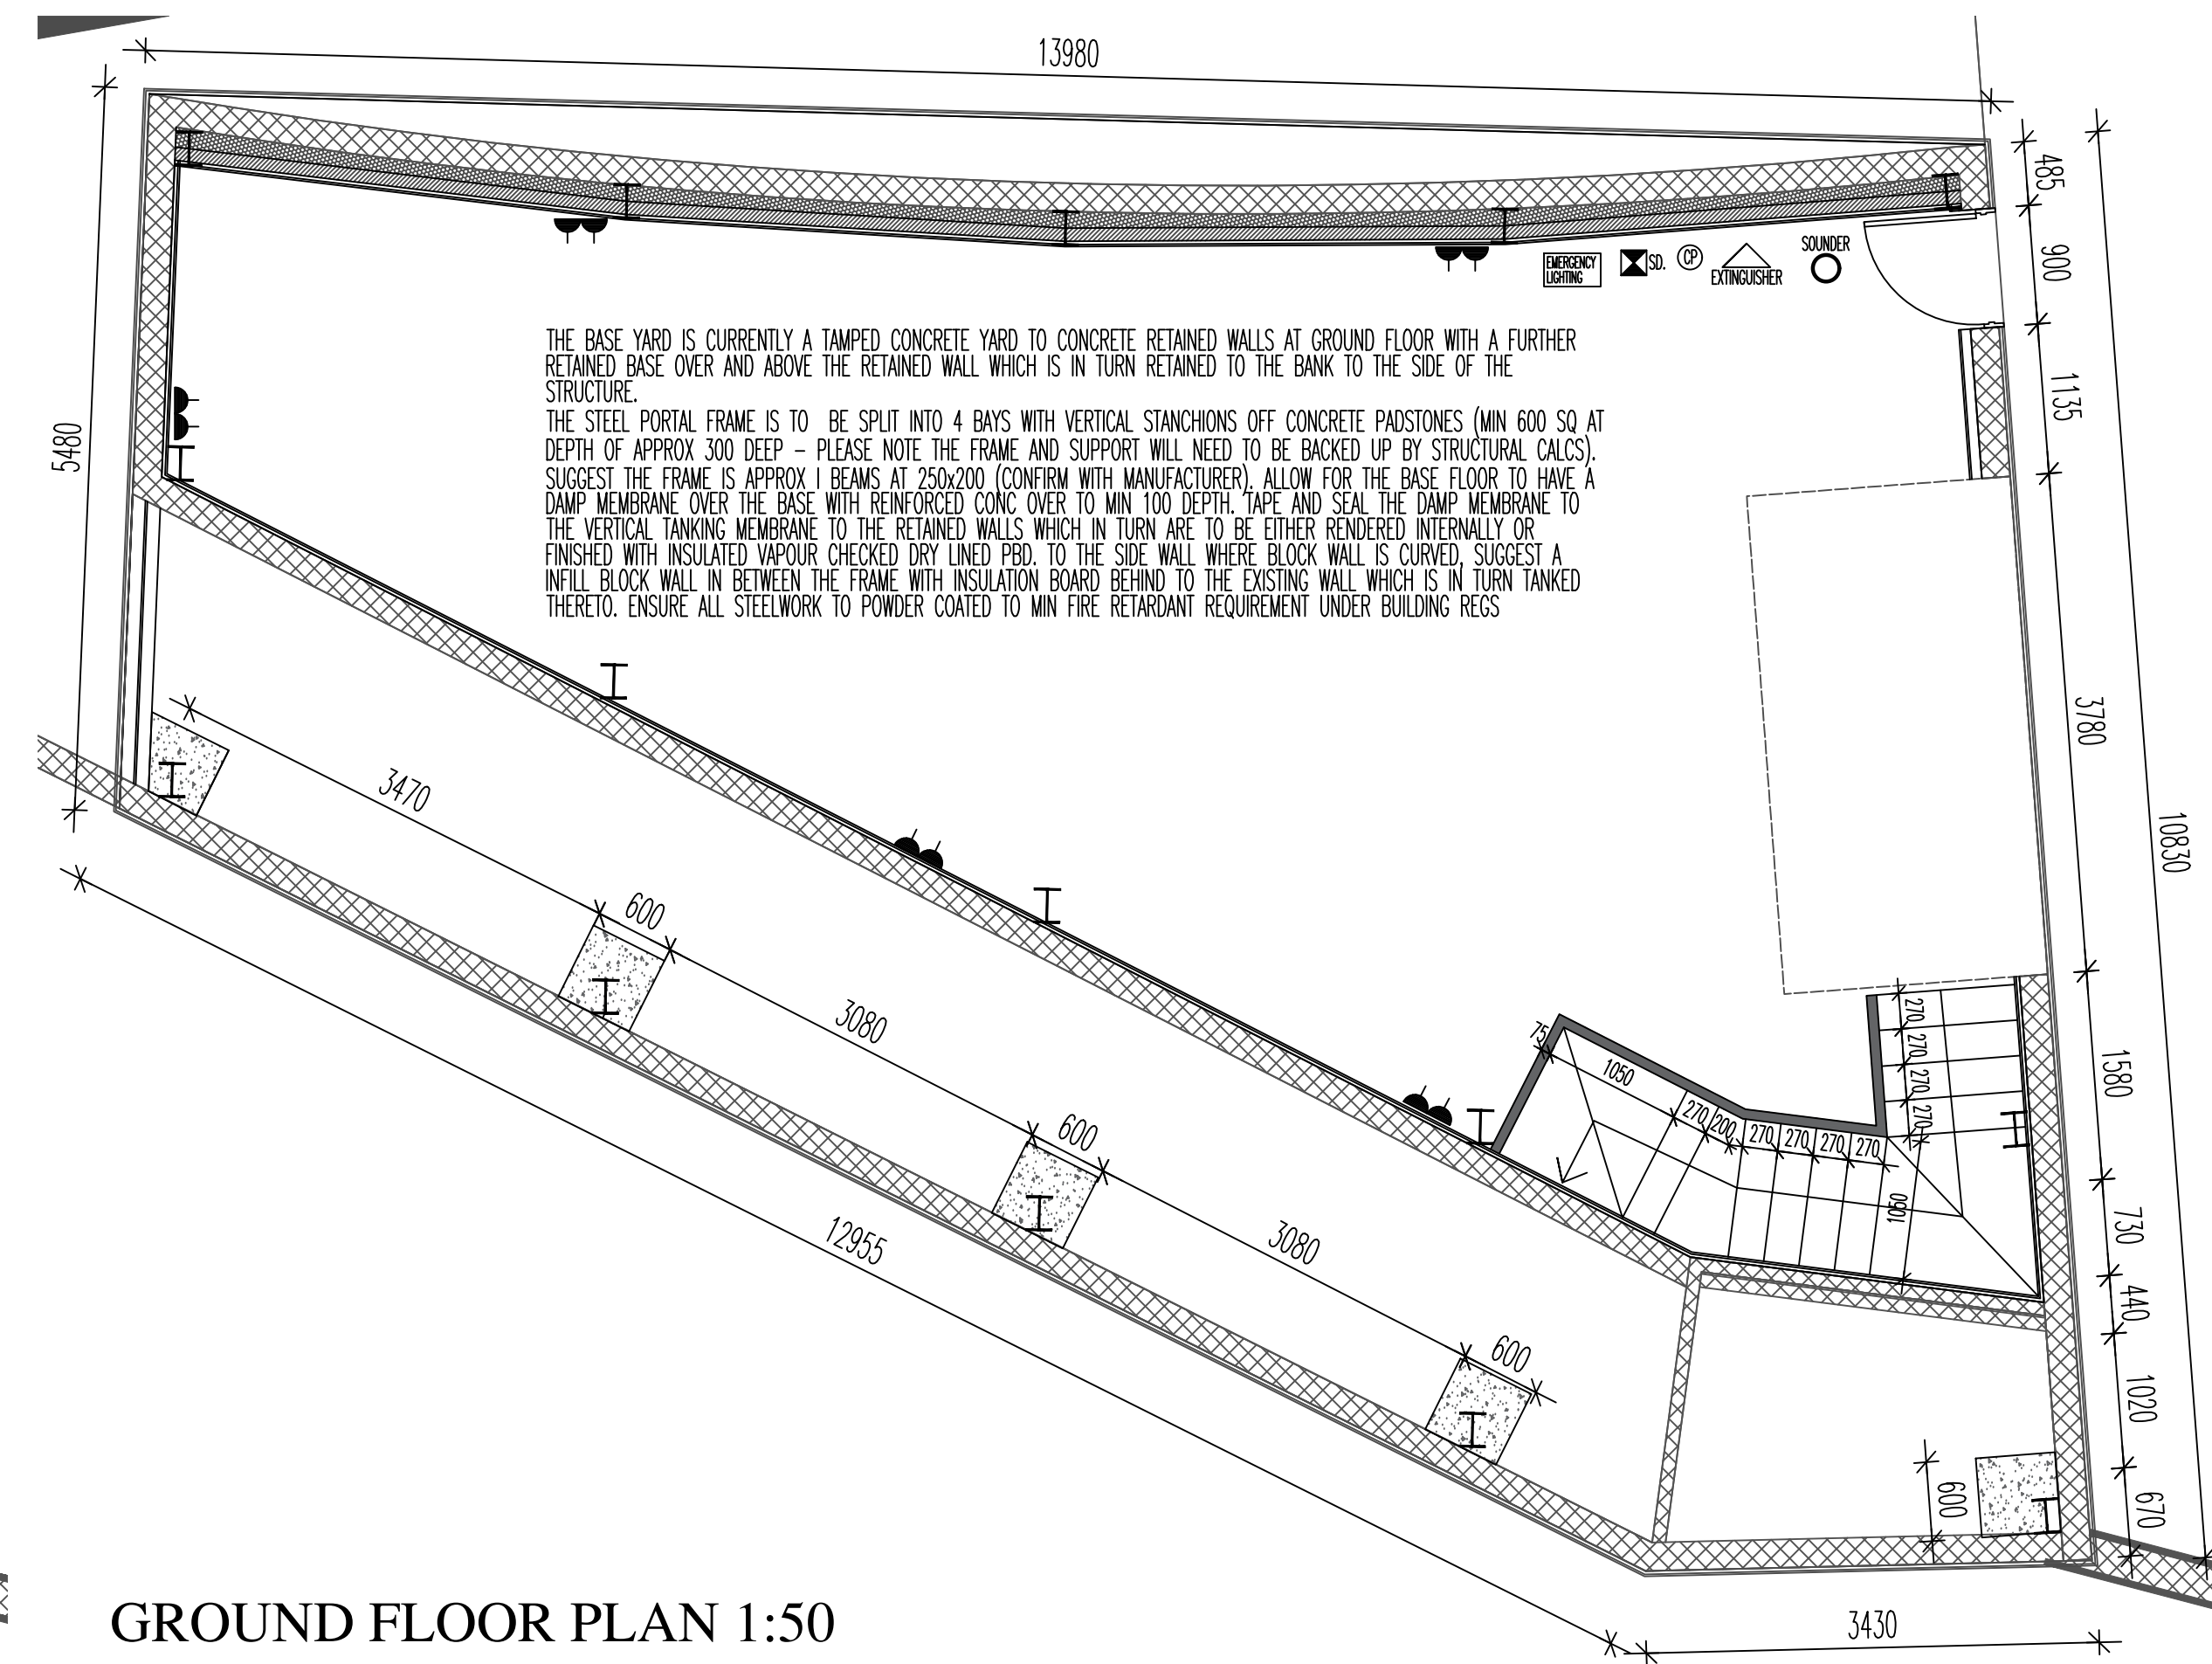

GROUND FLOOR PLAN 1:50

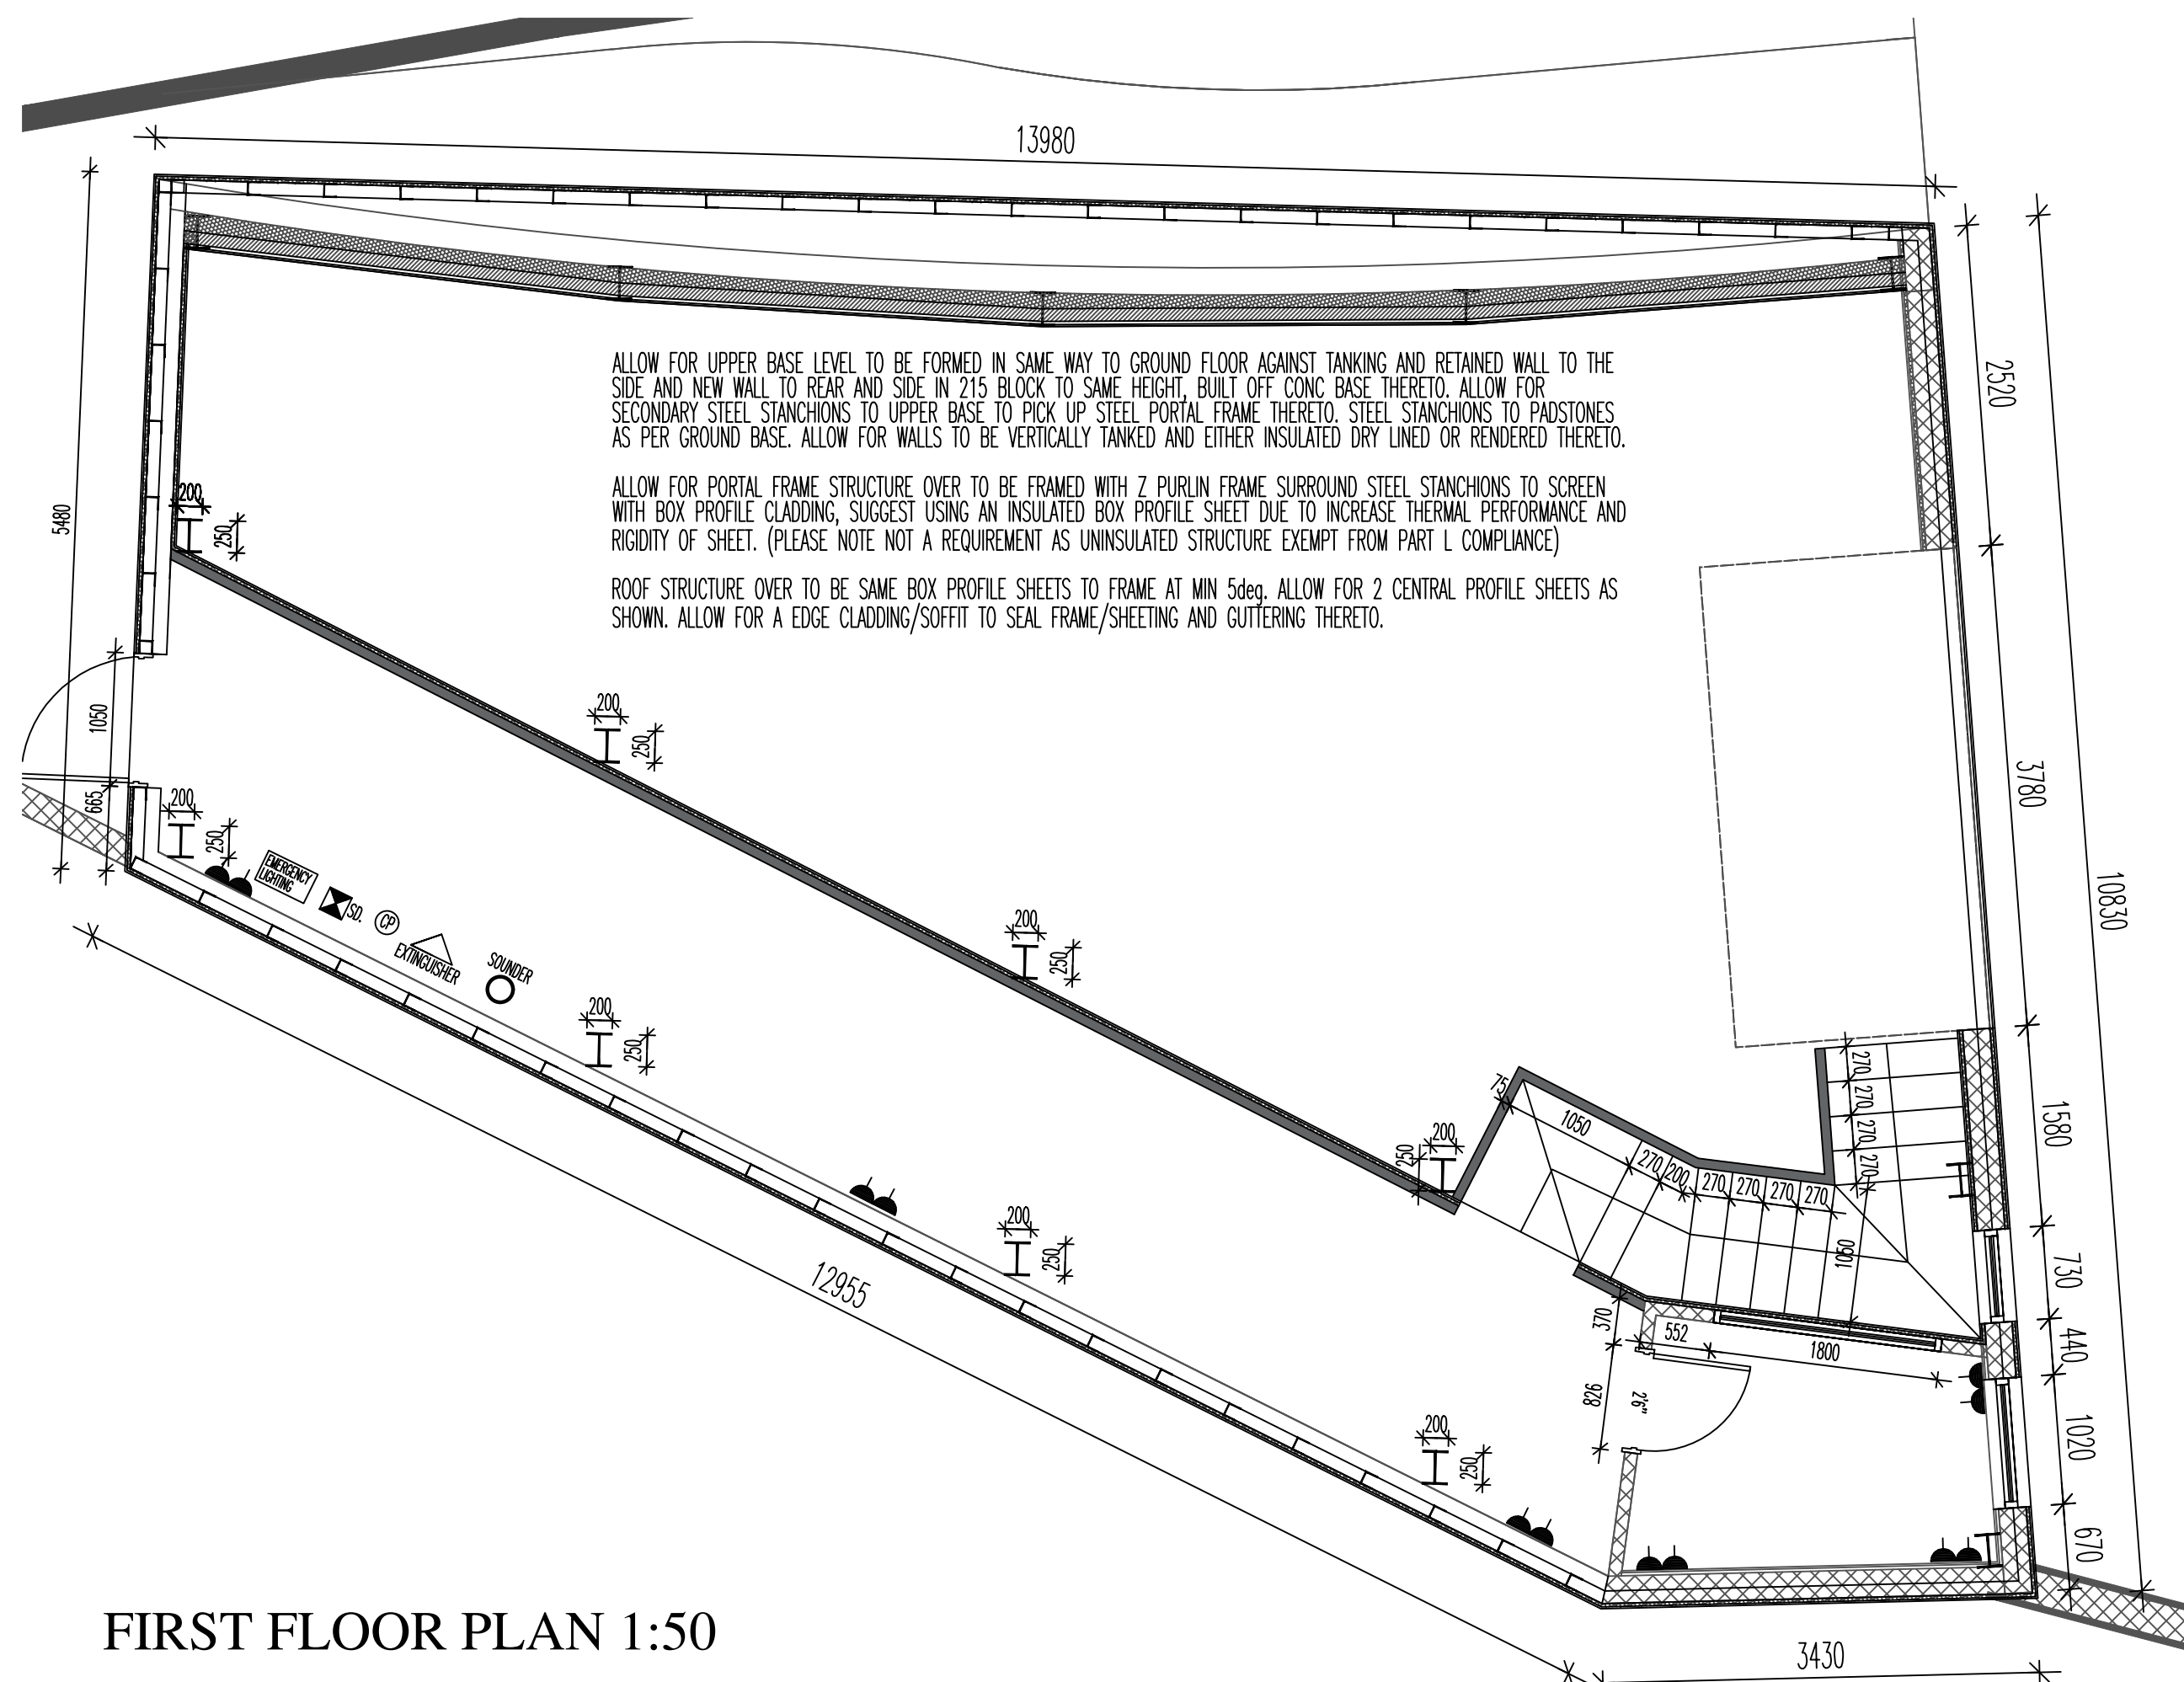

FIRST FLOOR PLAN 1:50

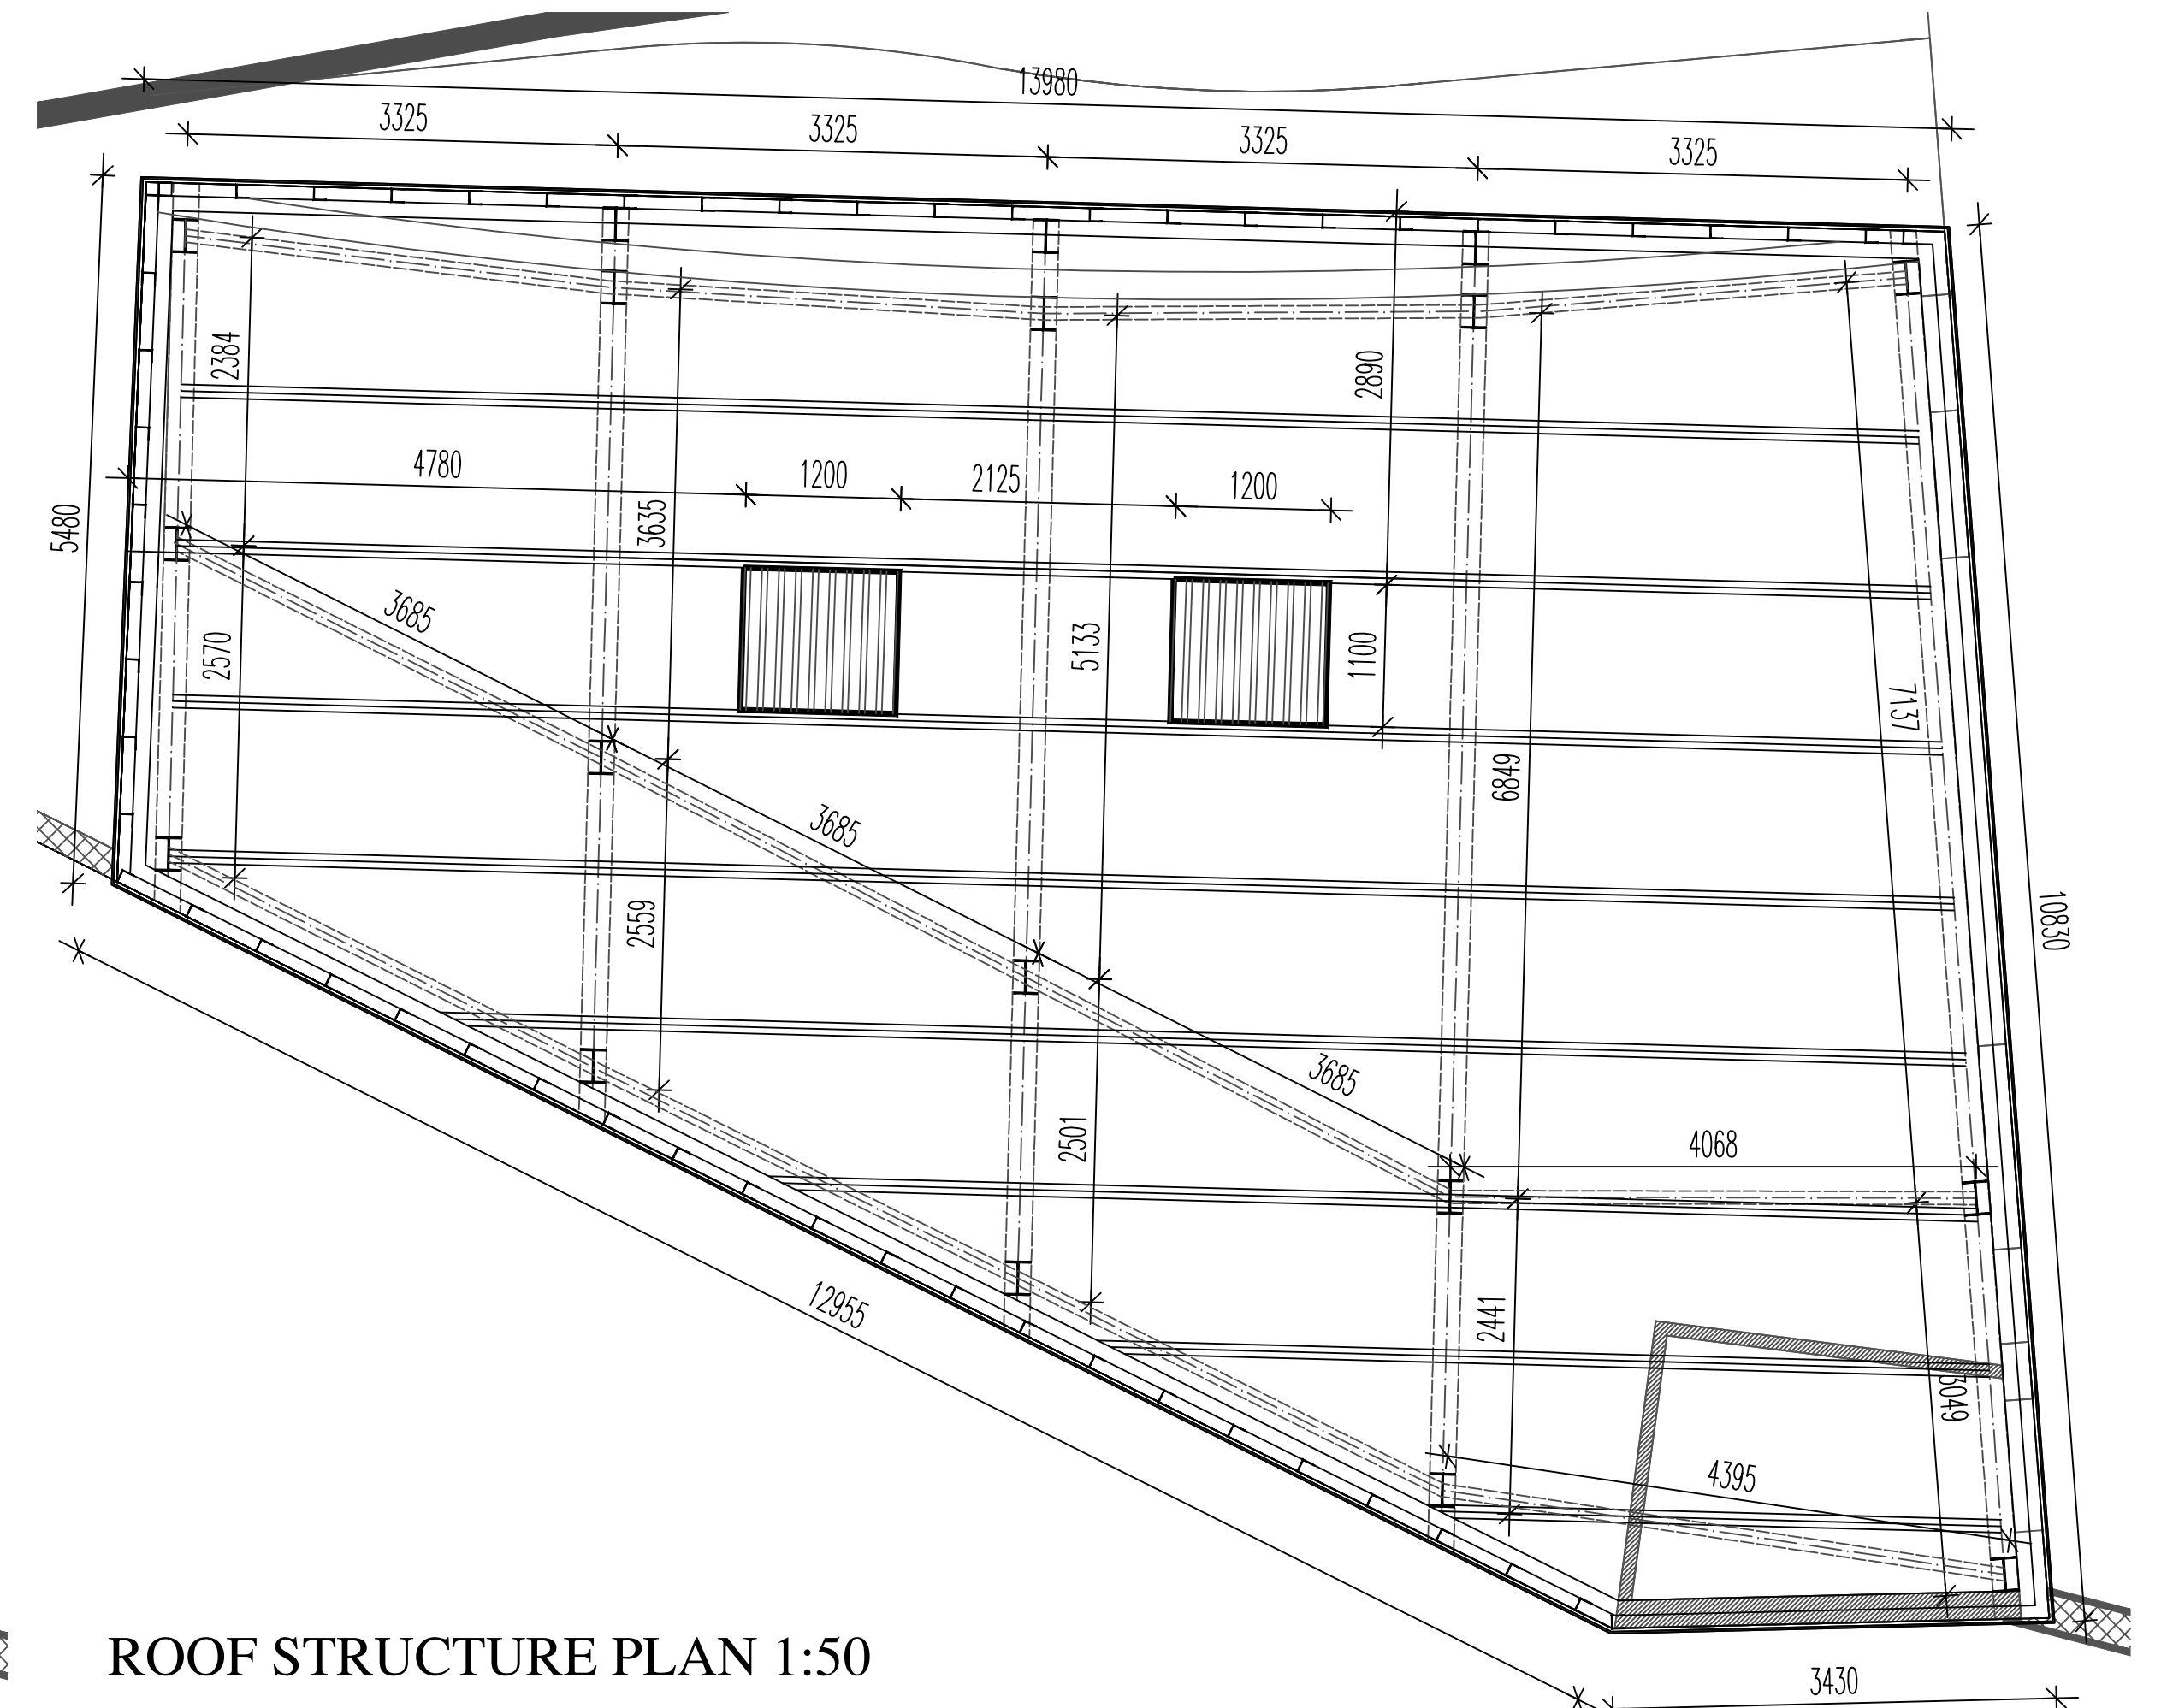

ROOF STRUCTURE PLAN 1:50

PROPOSED DETECTION:

- EMERGENCY LIGHTING ON FUSED CIRCUIT TO CUT IN ON ELECTRIC POWER FAILURE BS 5266
- INTEGRATED SMOKE DETECTORS ON MAINS BATTERY BACKUP
- MANUAL BREAK GLASS CALL POINTS FOR FIRE ALARM
- FIRE EXTINGUISHER POINTS TO APPROVAL OF FIRE OFFICER
- FIRE ALARM SOUNDER LINKED TO DETECTION

* NB: THE FIRE ALARM SYSTEM IS TO BE TO BS 5839 P11

 
VENTILATION & HEATING TO COMPLY WITH FOLLOWING:
HEATING & VENTILATION: IN ACCORDANCE WITH NON DOMESTIC BUILDING SERVICES GUIDE

REAR ESCAPE ROUTES TO HAVE IRONMONGERY FOR ESCAPE PURPOSES - IE SINGLE OPERATION SYSTEM - THUMB TURN ETC.

ENSURE THAT PROPRIETARY SOUND/FIRE PROTECTED COLLAR BOXINGS ARE USED TO ALL DOWNLIGHTERS IF USED - IF NOT PENDANT FITTINGS ARE TO BE USED

ALL ELECTRICAL WORKS IN ACCORDANCE WITH PART P AND RELEVANT BRITISH STANDARDS FOR COMMERCIAL GUIDELINES

THE ELECTRICAL POINTS ETC ARE FOR A GUIDE ONLY - CLIENT TO DISCUSS WITH ELECTRICAL CONTRACTOR FOR EXACT REQUIREMENTS - SUGGEST USE OF INTEGRATED SOCKET AND DATA POINTS TO ALL AREAS AS REQUIRED.



A.J.S ARCHITECTURE

32 carr road,
buxton,
derbyshire,
sk17 6wf.

h: 01298 26062
m: 07794 400237

DRAWING No: PROPOSED 02

GISBOURNE WORKS

GISBOURNE WORKS, WHALEY BRIDGE