



FRONT ELEVATION



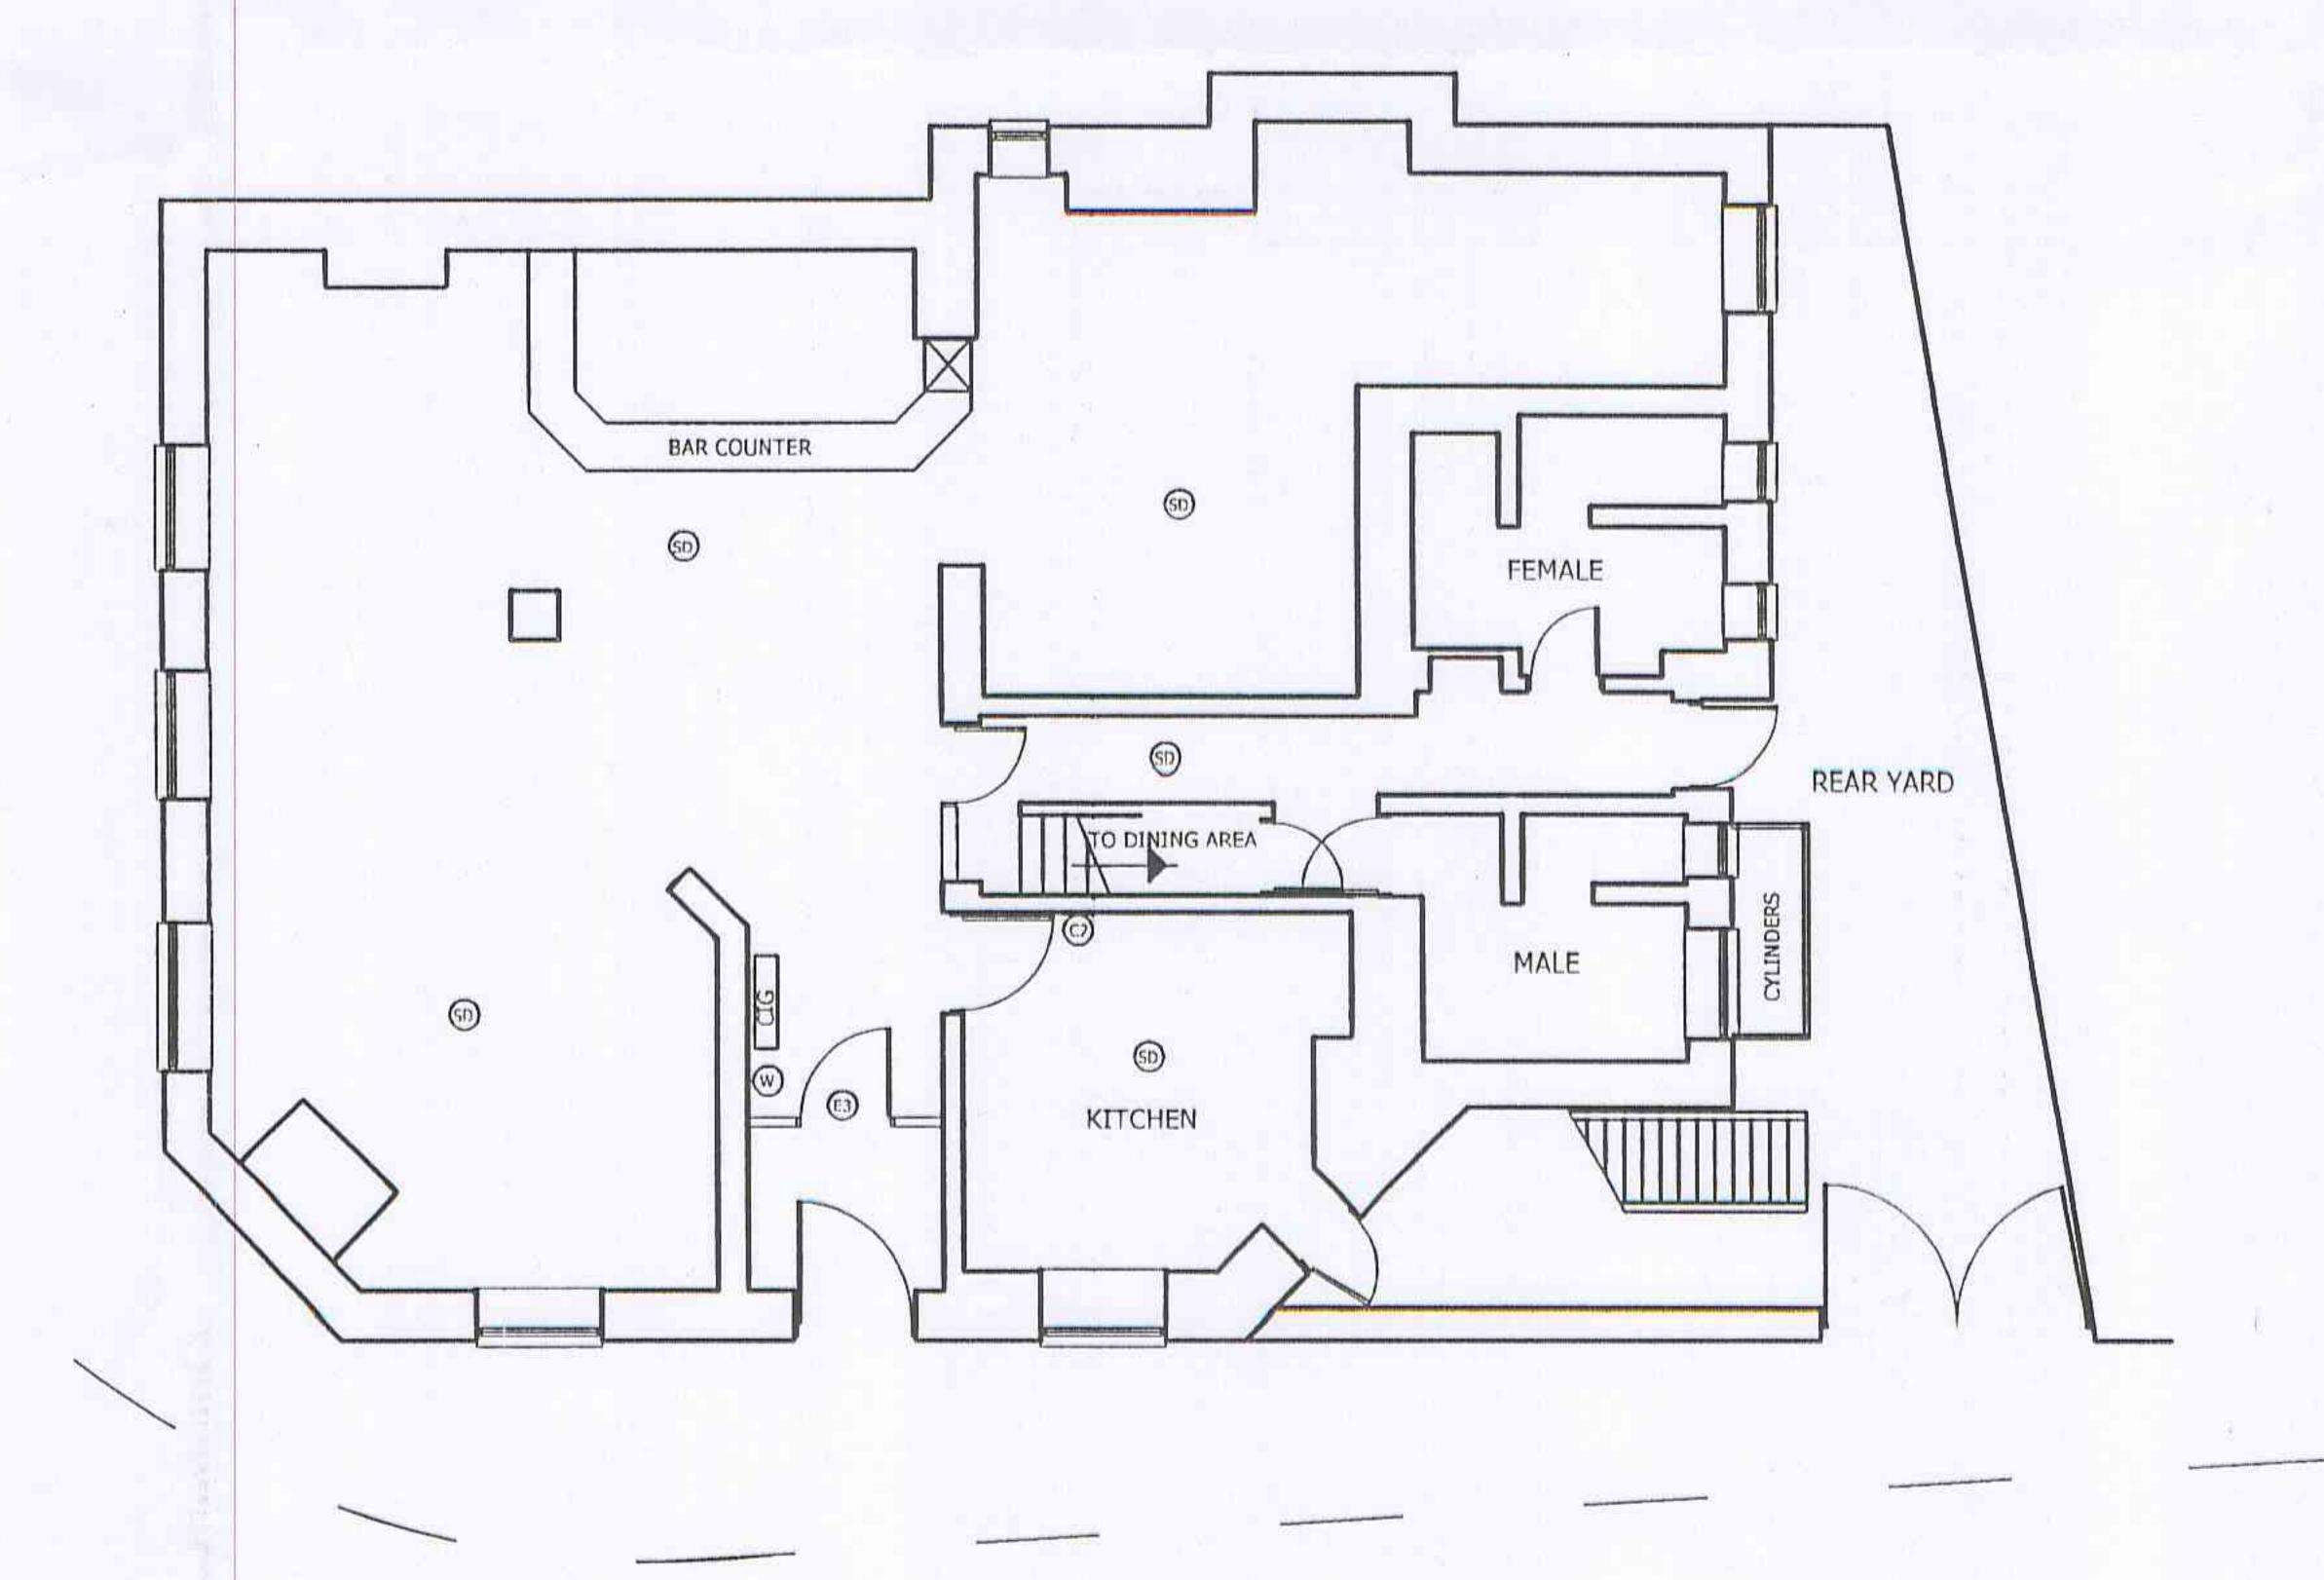

GROUND FLOOR PLAN

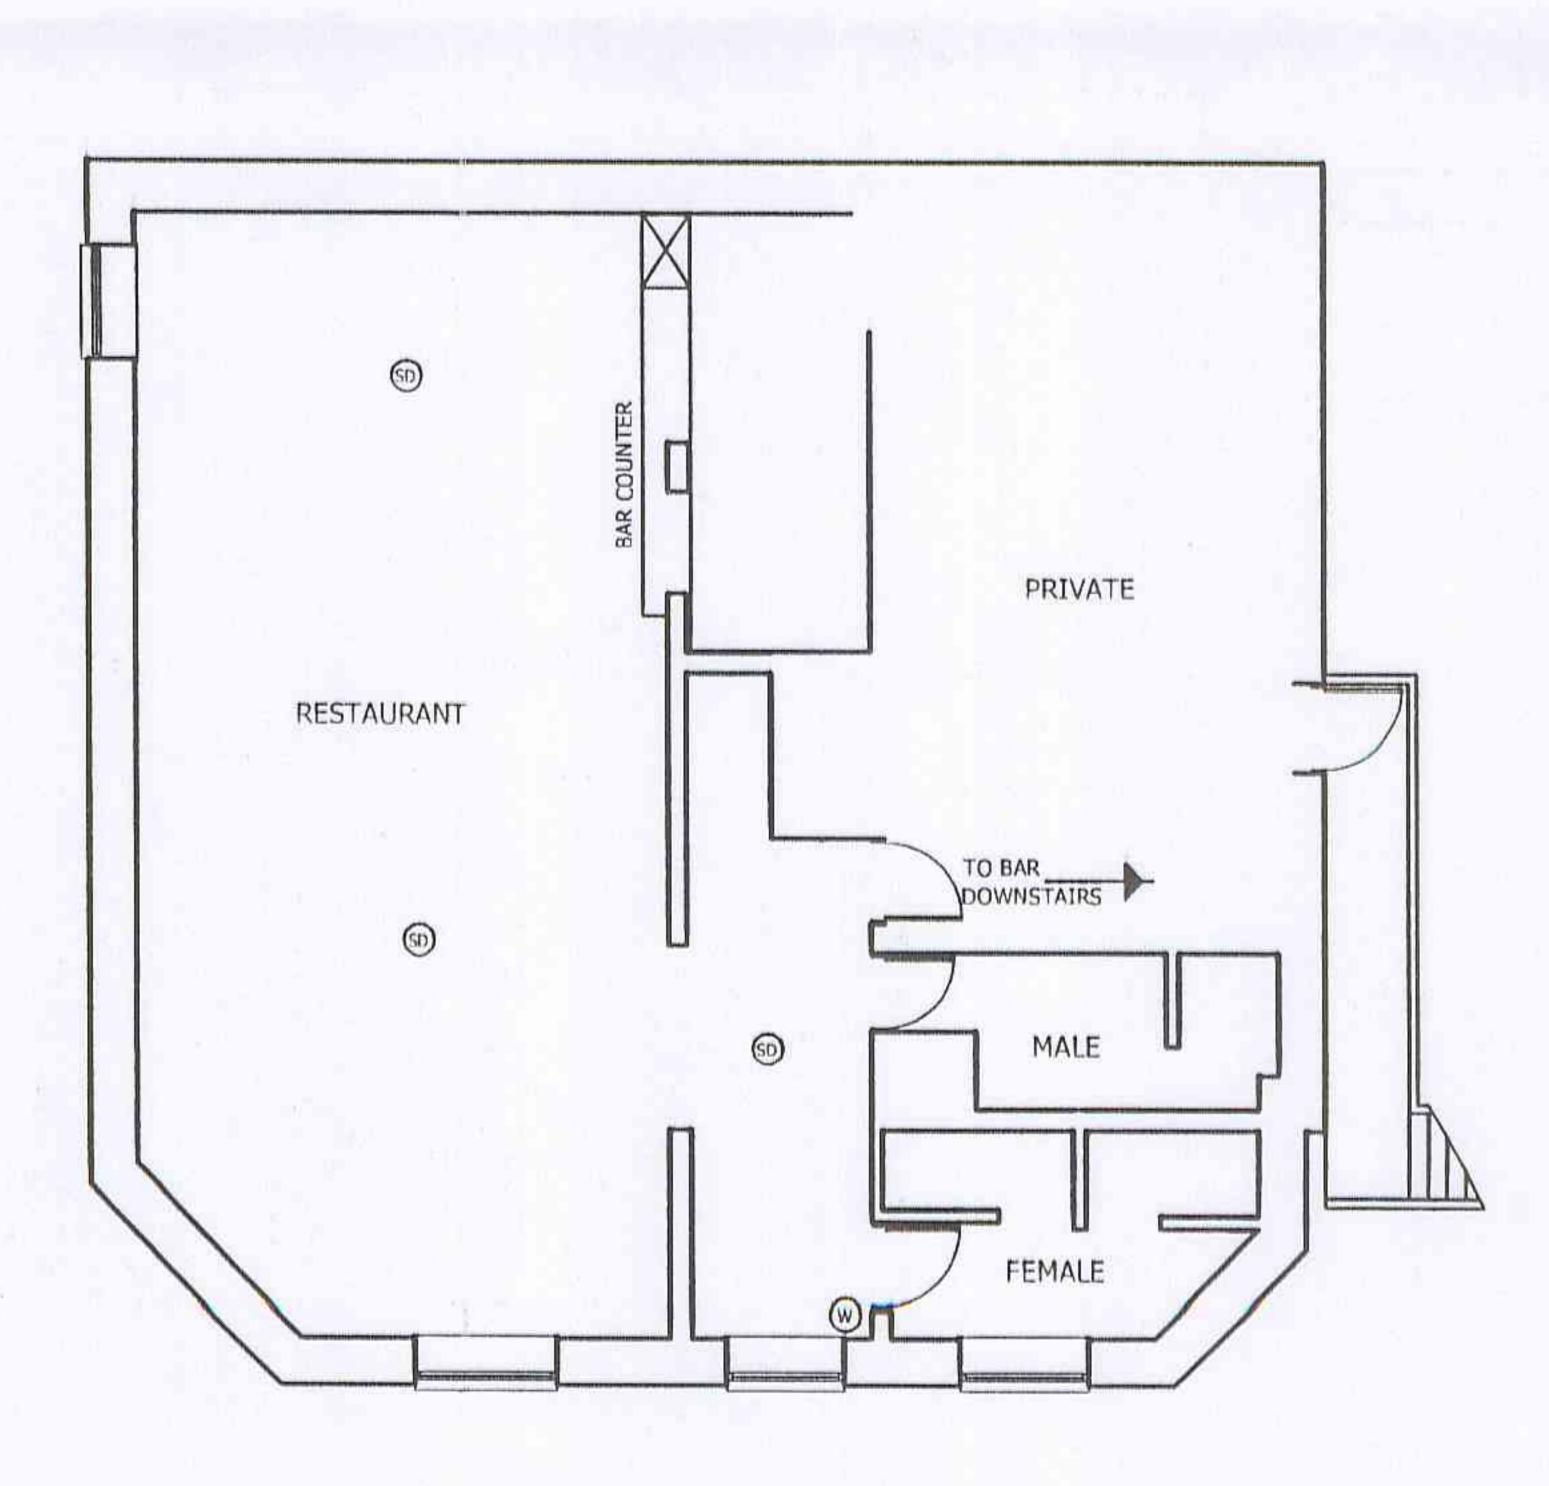

FIRST FLOOR PLAN

Do not scale from this drawing

The contractor is to check all dimensions on site, and report discrepancies to the designer All rights described in Chapter IV of the Copyright, Design and Patents Act 1988 have been generally asserted.

SD SMOKE DETECTOR W WATER EXTINGUISHER CO2 EXTINGUISHER ILLUMINATED 'EXIT' SIGN WITH DIRECTIONAL ARROW CIG CIGARETTE VENDING MACHINE

RFT Project Management

Stephen Hobson BSc FRICS

The Jumbles . 82 Wellington Road . Turton Bolton . Lancashire . BL7 0EF Mob: 07960 207431 Email: steveh@rftpm.com Tel: 01204 856947 Fax: 01204 856948

PUNCH BARS AND RESTAURANTS

 
PROJECT

Queens Arms 1 Shepley Street Old Glossop SK13 7RZ

DRAWING TITLE

Plan and Elevations as Existing

SCALE DATE DRAWN BY



Control of the contro

Do not scale from this drawing

The contractor is to check all dimensions on site, and report discrepancies to the designer All rights described in Chapter IV of the Copyright, Design and Patents Act 1988 have been generally asserted.

All timber to be "tana-toned" treated redwood.

Heater to be a Tansun 1.3 KW IP54 wall mounted Algarve quartz patio heater

Lighting to be 2 no. Tornado IP54 100watt GLS wall light on a motion sensor, linked back to control swith located in bar area.

Stub bins to be sited adjacent to canopy

Existing lock to side door to be adjusted for use from outside as well as inside

THERE BEAK BOROLIGH CONTRACT.

2 9 MAY 2001

LINIA BIOTHER.

KE.

SMOKE DETECTOR

WATER EXTINGUISHER

© CO2 EXTINGUISHER

© ILLUMINATED 'EXIT' SIGN WITH DIRE

CIG CIGARETTE VENDING MACHINE

REVISIONS

RFT Project Management

Stephen Hobson BSc FRICS

The Jumbles , 82 Wellington Road , Turton
Bolton , Lancashire , BL7 0EF
Mob: 07960 207431 Email: steveh@rftpm.com
Tel: 01204 856947 Fax: 01204 856948

CLIE

PUNCH BARS AND RESTAURANTS

PROJECT

Queens Arms
1 Shepley Street
Old Glossop

DRAWING TITLE

Plan and Elevations as Proposed

SCALE DATE DRAWN BY
1:100 MAY 07 RM

DRAWING

ESP-300376-02