


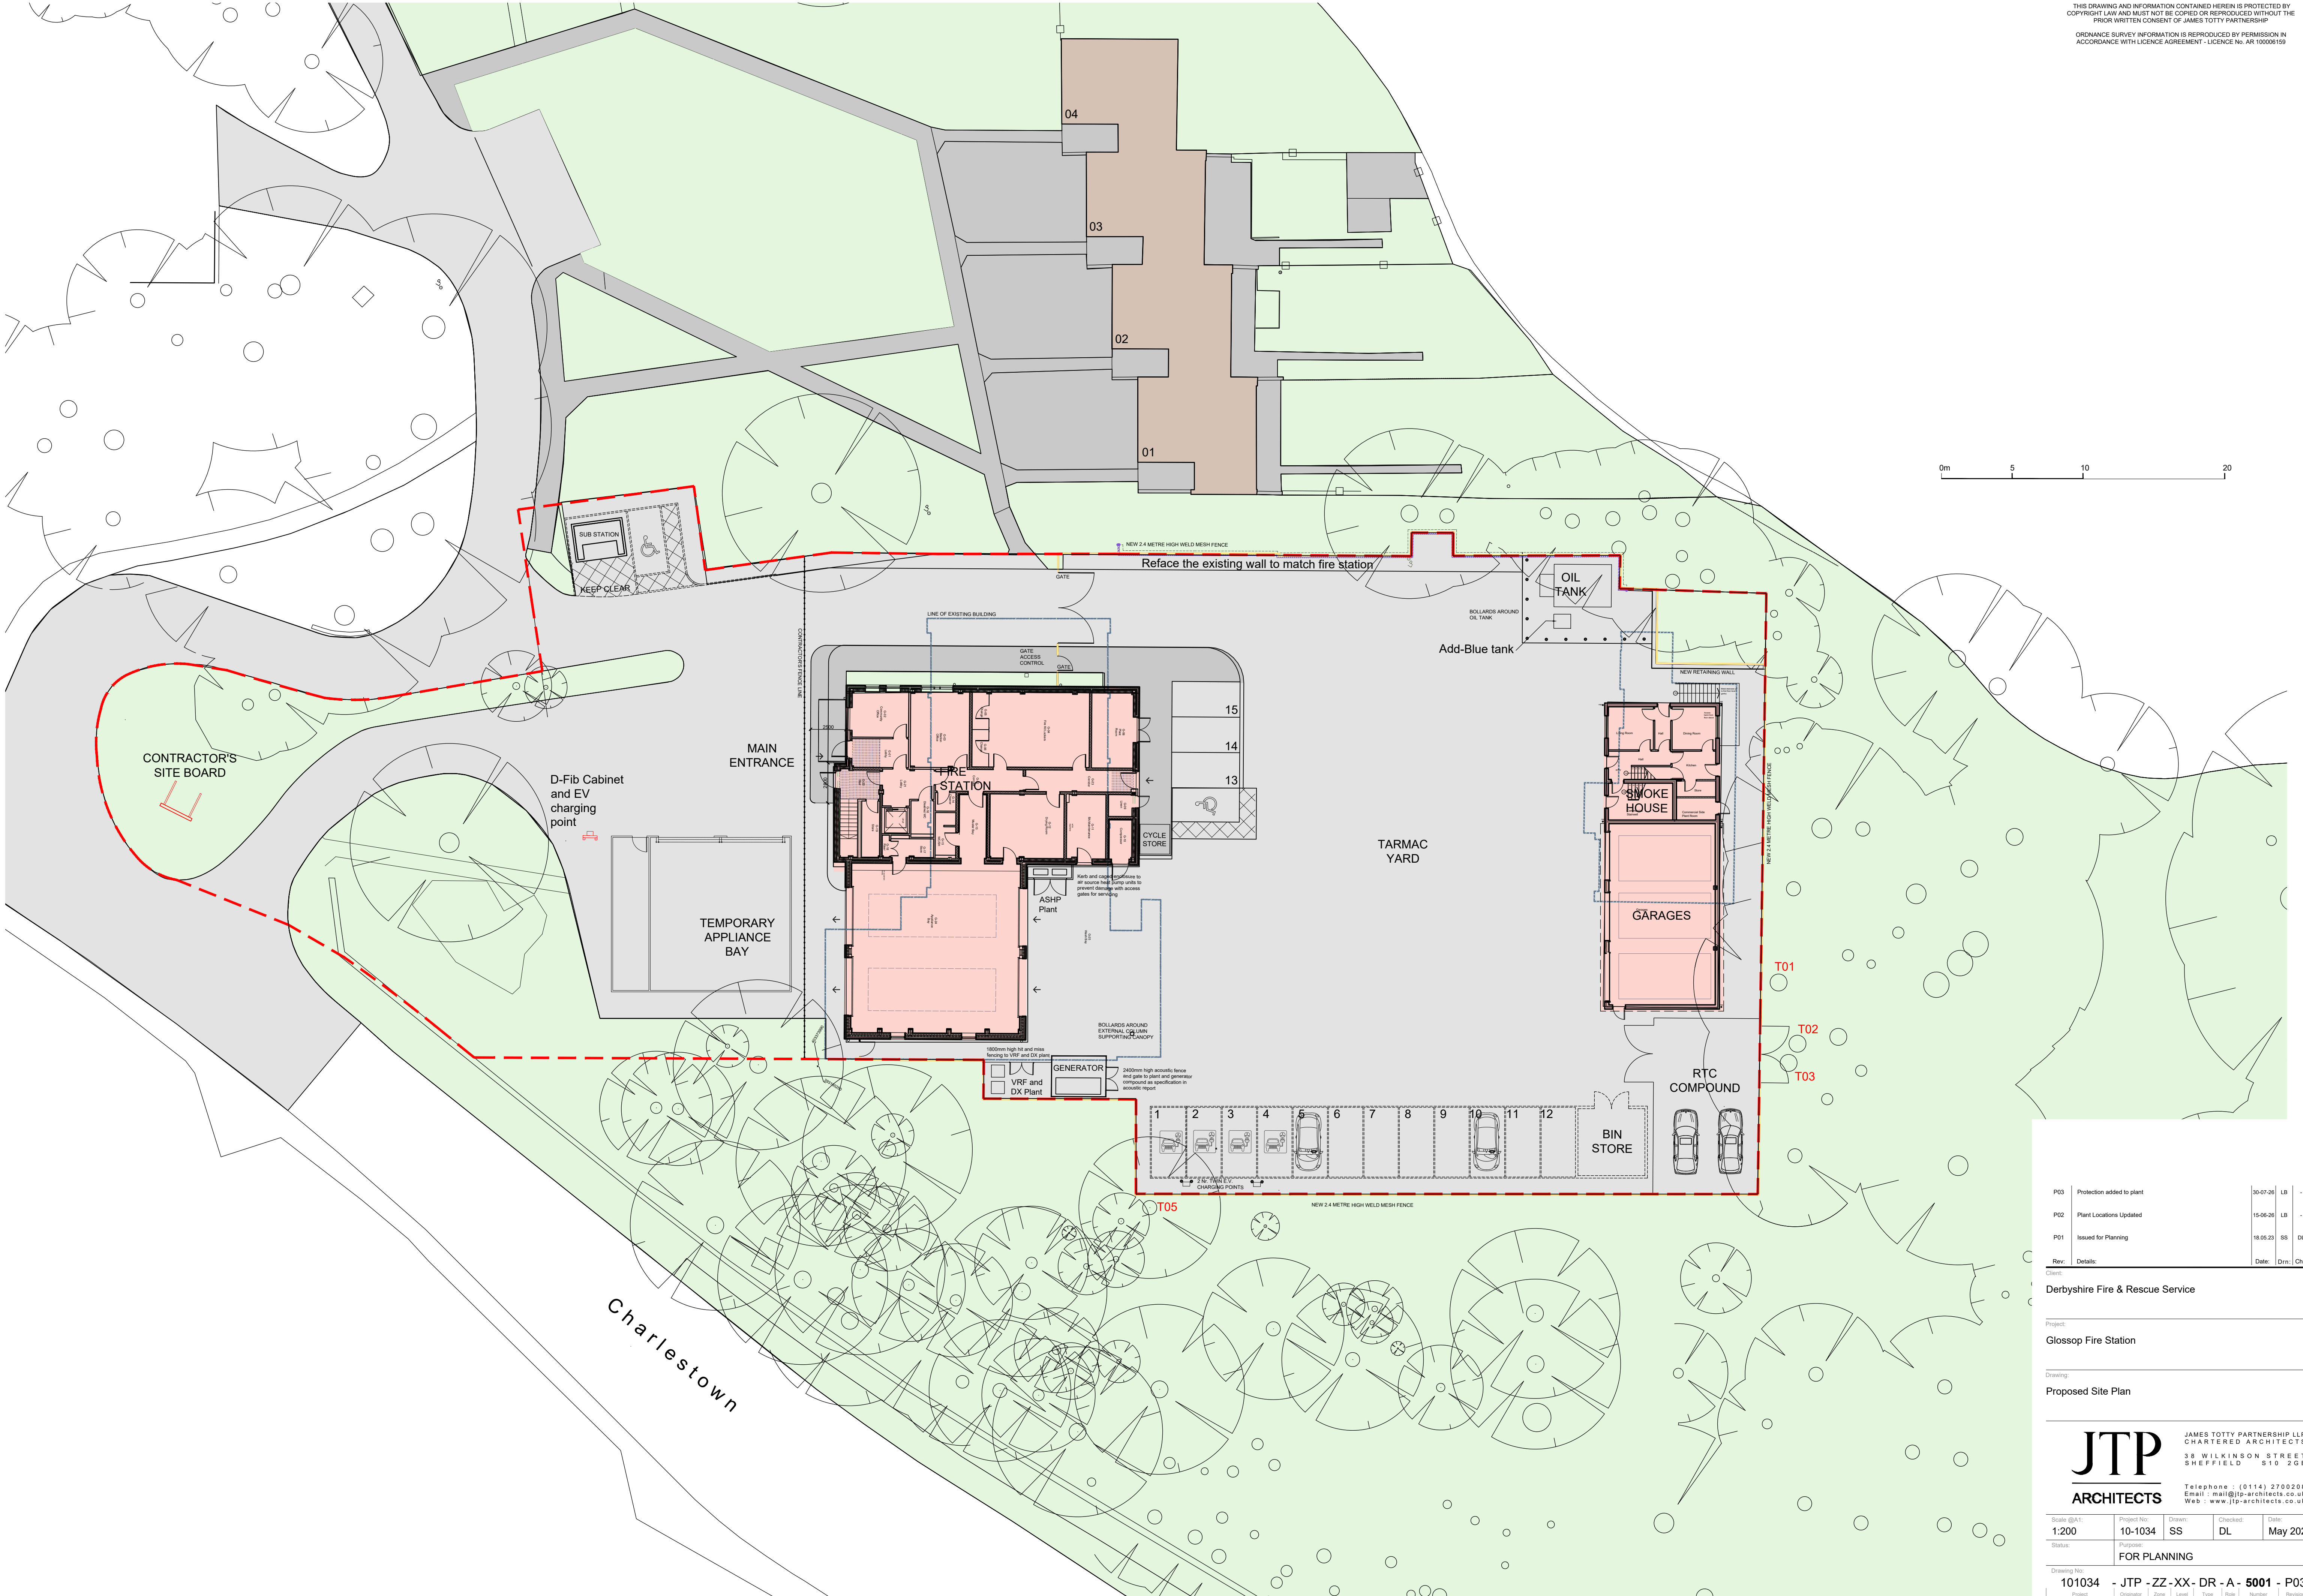

P03	Protection added to plant	30-07-26	LB	-
P02	Plant Locations Updated	15-06-26	LB	-
P01	Issued for Planning	18.05.23	SS	DL
Rev:	Details	Date:	Drn:	Chk:

Client:

Derbyshire Fire & Rescue Service

Project:

Glossop Fire Station

Drawing:

Proposed Site Plan

JTP
ARCHITECTS

JAMES TOTTY PARTNERSHIP LLP
CHARTERED ARCHITECTS
38 WILKINSON STREET
SHEFFIELD S10 2GB

Telephone : (0114) 2700208
Email : mail@jtp-architects.co.uk
Web : www.jtp-architects.co.uk

Scale: @A1: 1:200	Project No: 10-1034	Drawn: SS	Checked: DL	Date: May 2023
Status:	FOR PLANNING			
Drawing No:	101034 - JTP - ZZ - XX - DR - A - 5001 - P03			